


THE COPYRIGHT OF THIS DRAWING REMAINS THE PROPERTY OF THE ELECTRICAL DESIGN GROUP.

USE FIGURED DIMENSIONS IN PREFERENCE TO SCALE.

ALL DIMENSIONS TO BE VERIFIED ONSITE.

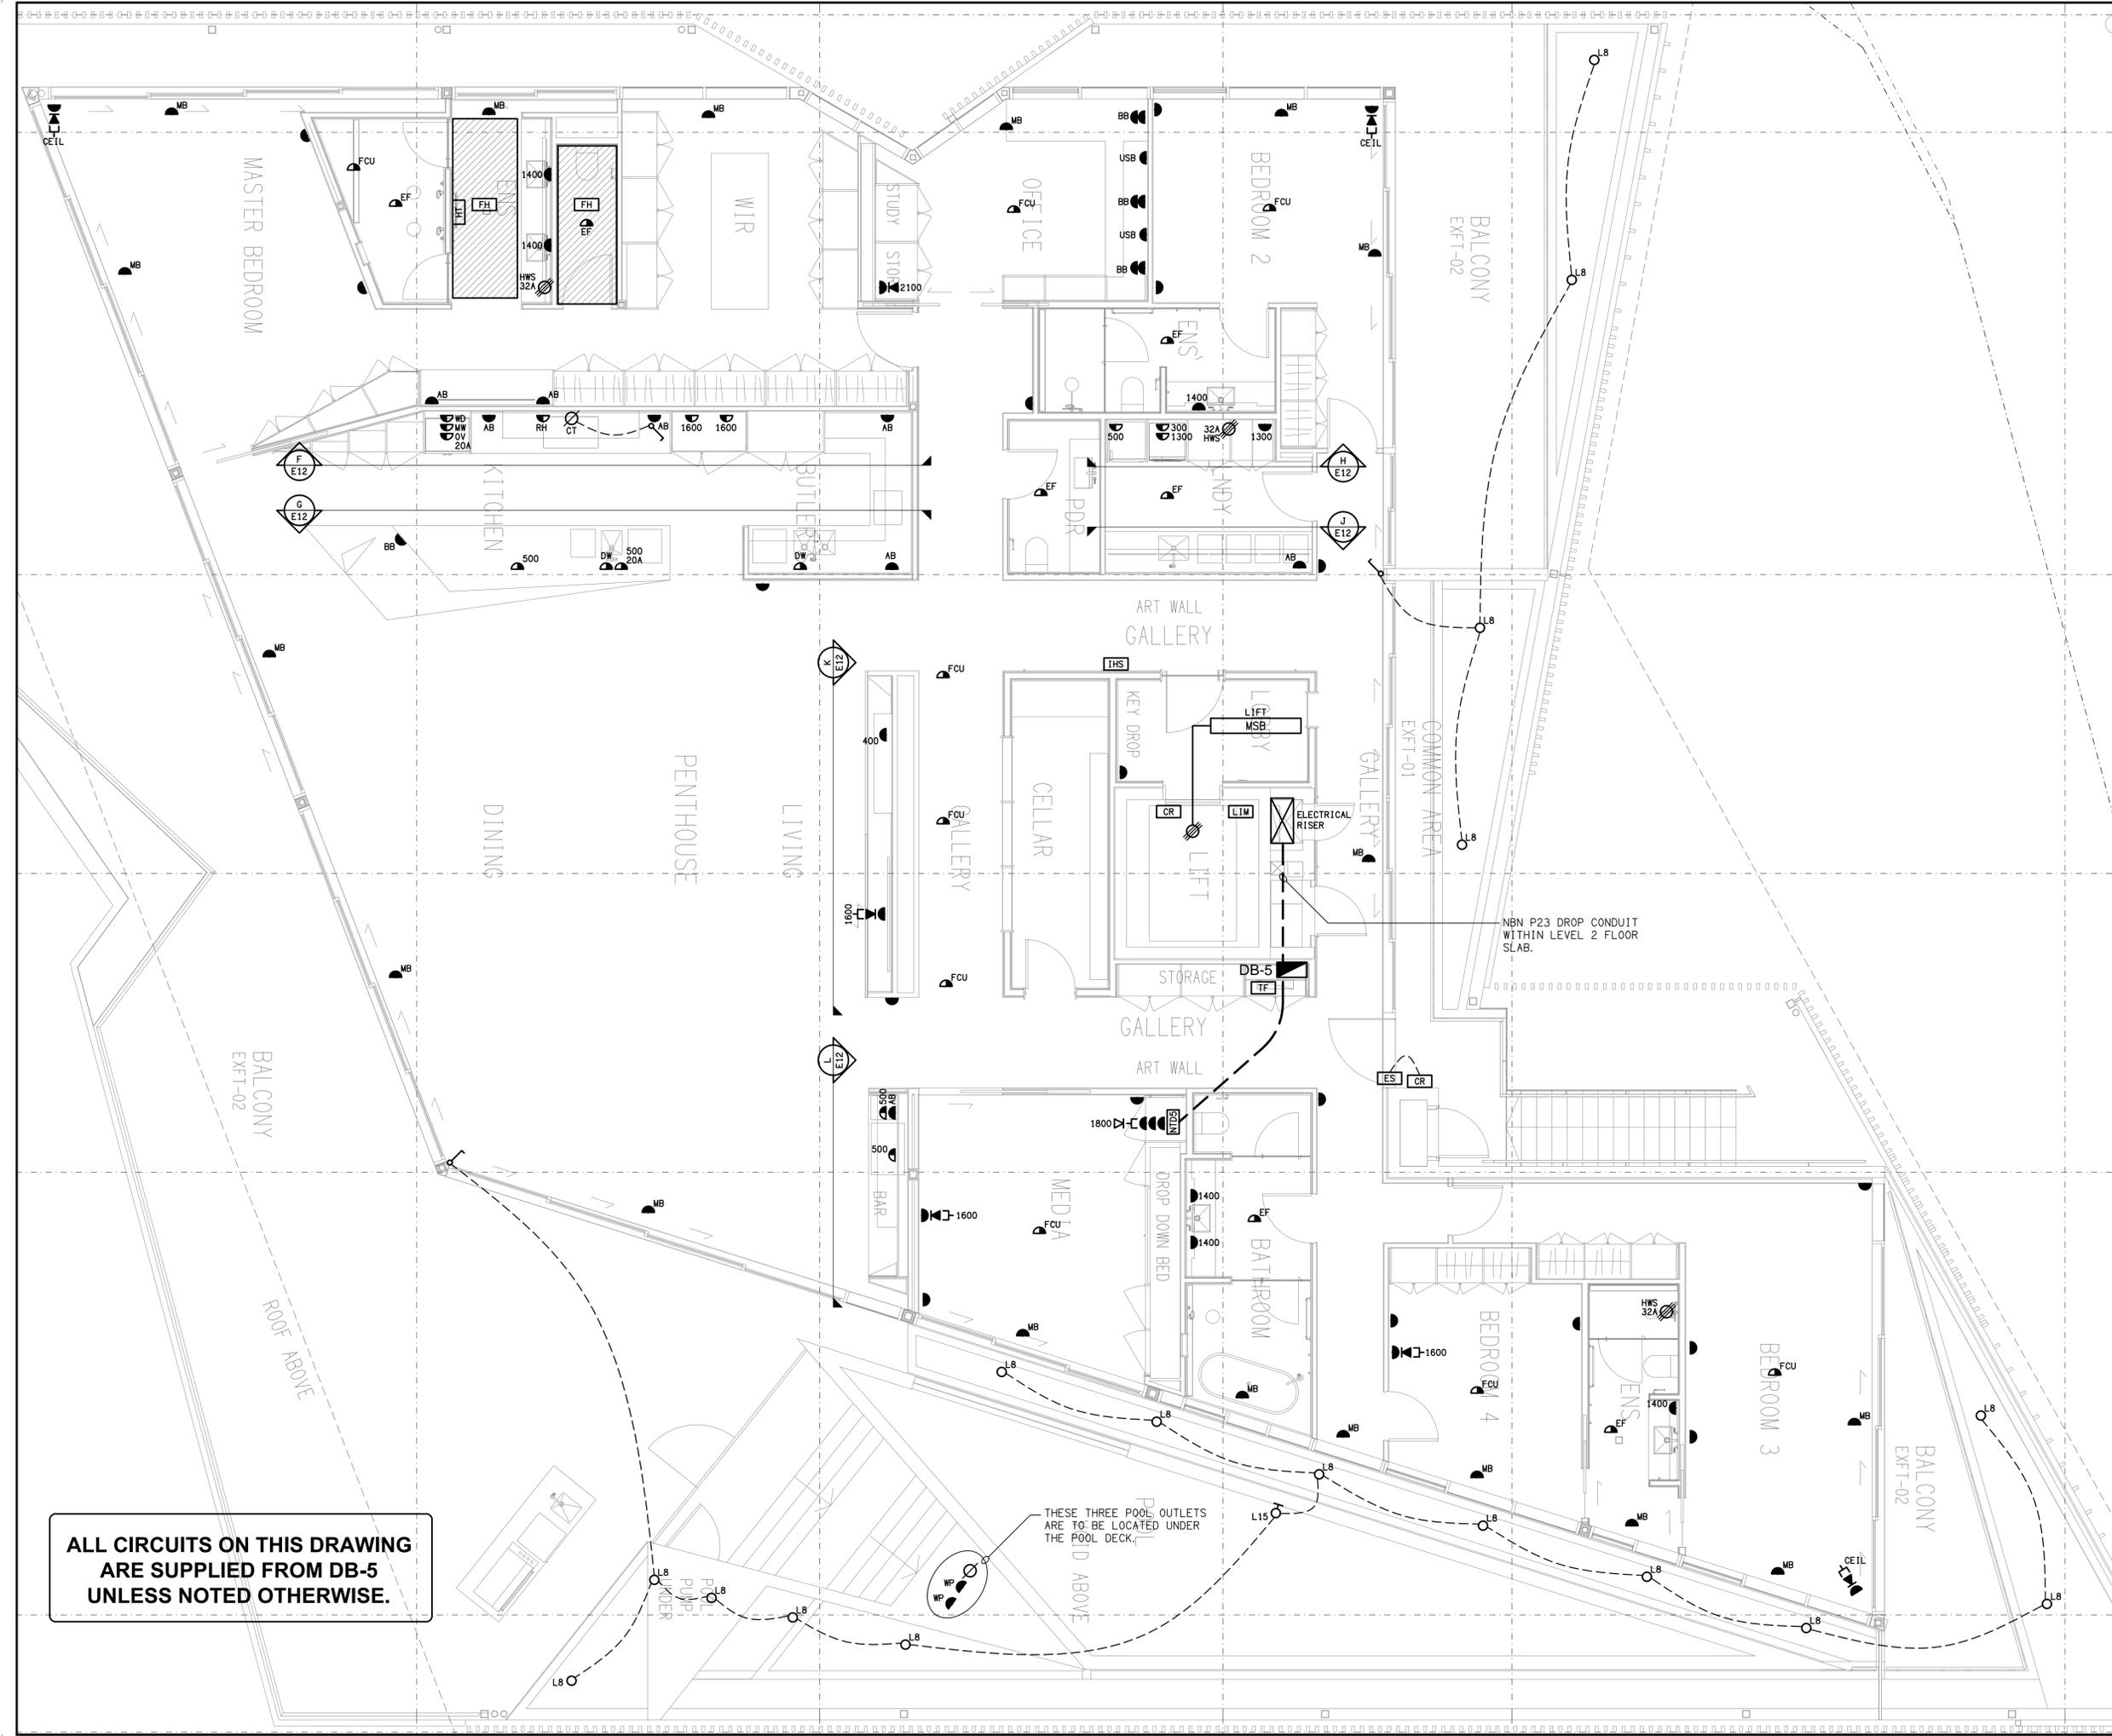

**ALL CIRCUITS ON THIS DRAWING  
ARE SUPPLIED FROM DB-5  
UNLESS NOTED OTHERWISE.**

|      |              |            |
|------|--------------|------------|
| B    | TENDER       | 26/02/2026 |
| REV: | DESCRIPTION: | DATE:      |

**ELECTRICAL DESIGN GROUP**  
ELECTRICAL BUILDING SERVICES CONSULTANTS

BRISBANE: P.O. Box 15, Sherwood Qld 4075  
Phone: (07) 3278 4375  
Email: brisbane@edg.net.au  
Web: www.edg.net.au

ELECTRICAL DESIGN GROUP BRISBANE PTY LTD  
ACN 092 710 793

TRADING AS:  
ELECTRICAL DESIGN GROUP

PROJECT:  
**TI-TREE COLLECTIVE**

SITE ADDRESS:  
294-298 GIVEN TERRACE, PADDINGTON  
BRISBANE, QUEENSLAND

SCALE: 1:50 SHEET SIZE: AT A1

DRAWING TITLE:  
**ELECTRICAL SERVICES  
LEVEL 2  
FLOOR PLAN**

PROJECT NO. DRAWING NO. REVISION:  
**C3599a E10 B**