




**EXISTING ELECTRICAL SERVICES WITHIN THIS AREA TO BE REMOVED UNLESS NOTED OTHERWISE.**

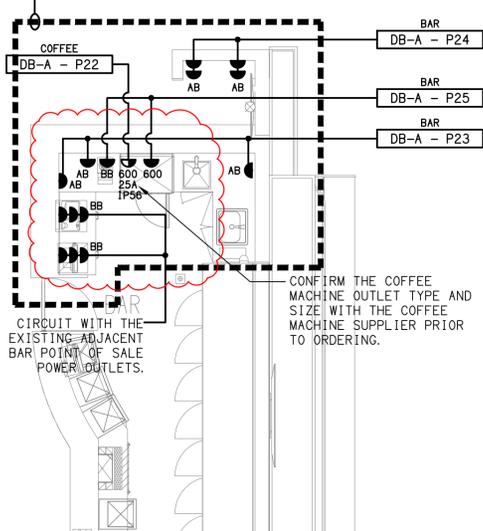


**DETAIL A**  
BISTRO BAR FLOOR PLAN  
SCALE 1:50

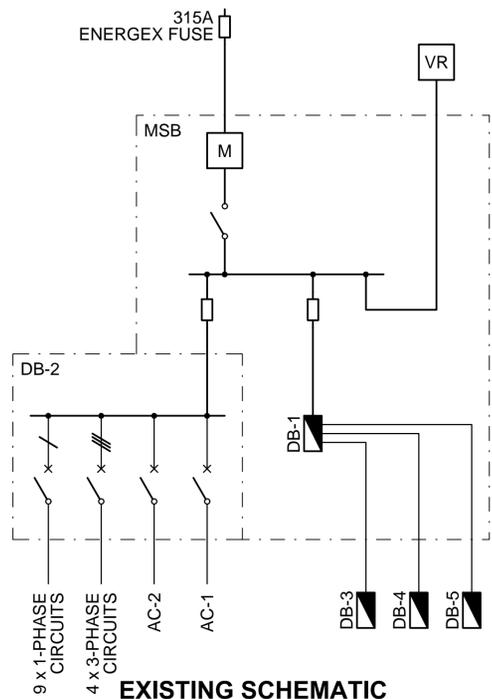


**EXISTING SCHEMATIC**  
POWER CONFIGURATION  
NOT TO SCALE

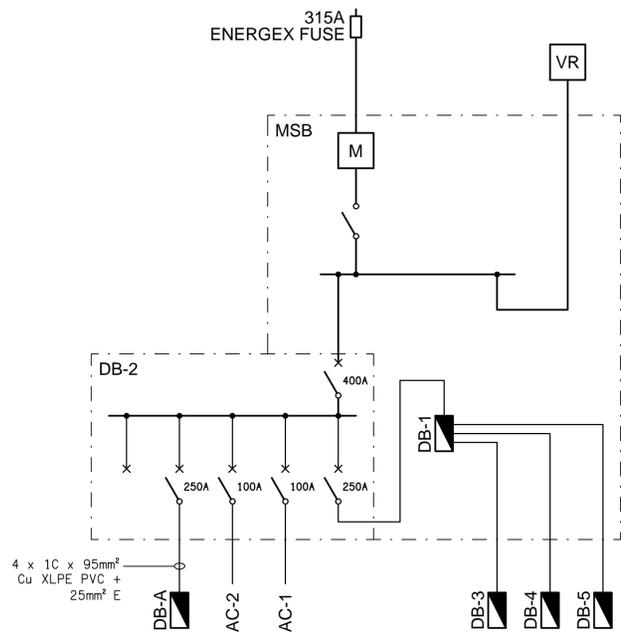


**PROPOSED SCHEMATIC**  
POWER CONFIGURATION  
NOT TO SCALE

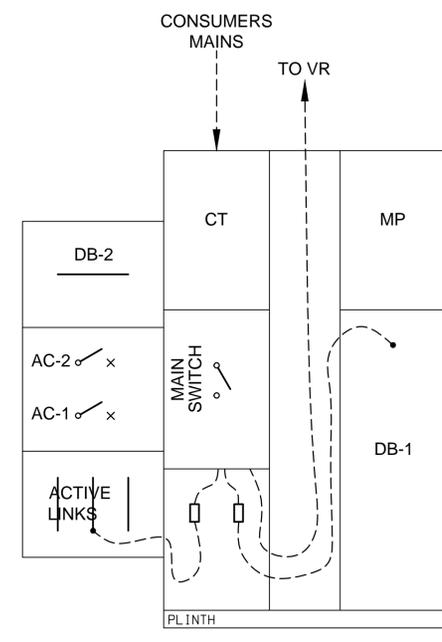

**EXISTING ELEVATION**  
MSB CONFIGURATION  
NOT TO SCALE

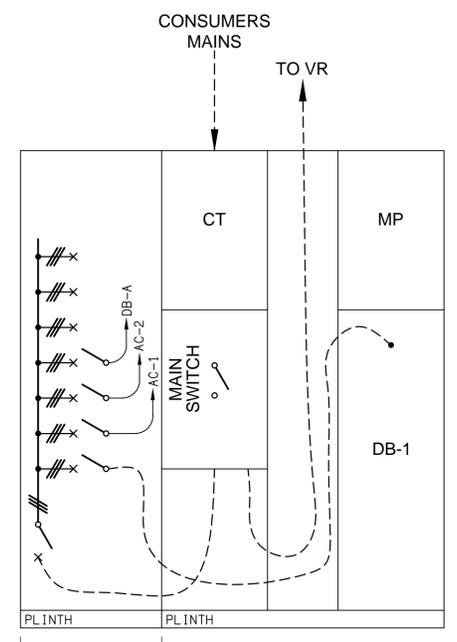

**PROPOSED ELEVATION**  
MSB CONFIGURATION  
NOT TO SCALE

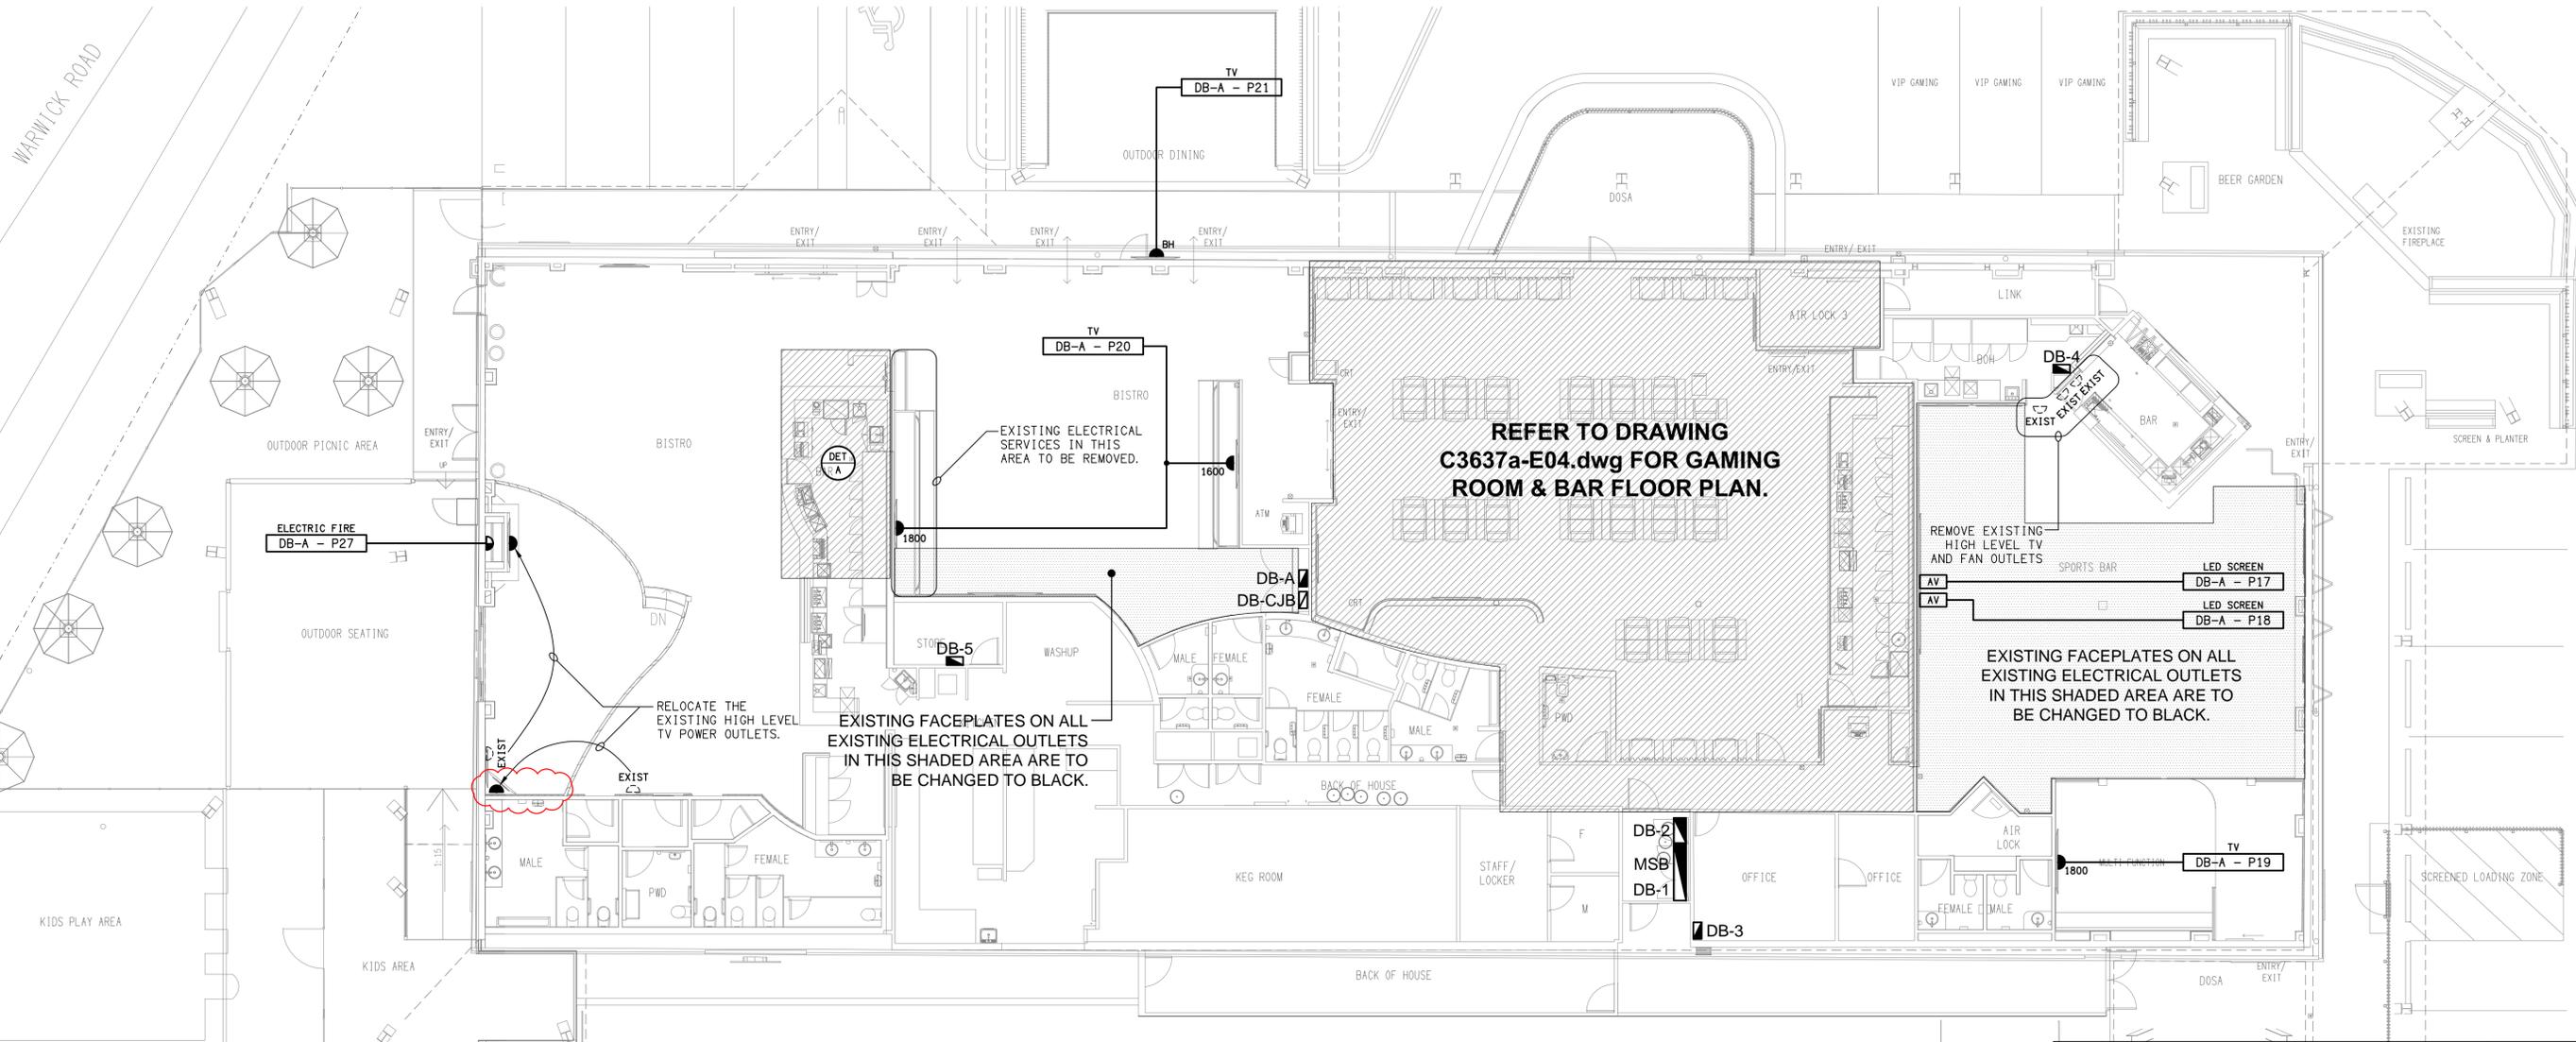

ELECTRICAL DESIGN GROUP BRISBANE PTY LTD  
ACN 092 710 793  
TRADING AS:  
ELECTRICAL DESIGN GROUP

THE COPYRIGHT OF THIS DRAWING REMAINS THE PROPERTY OF THE ELECTRICAL DESIGN GROUP.  
USE FIGURED DIMENSIONS IN PREFERENCE TO SCALE.  
ALL DIMENSIONS TO BE VERIFIED ONSITE.

**ELECTRICAL DESIGN GROUP**  
ELECTRICAL BUILDING SERVICES CONSULTANTS  
BRISBANE GOLD COAST

P.O. Box 15, Sherwood Q.4075  
Phone: (07) 3278 4375  
Email: brisbane@edg.net.au  
Web: www.edg.net.au

PROJECT:  
YAMANTO TAVERN

502-510 WARWICK ROAD, YAMANTO, QUEENSLAND

C CONSTRUCTION 23/02/2026  
REV. DESCRIPTION DATE

DRAWING:  
**ELECTRICAL SERVICES FLOOR PLAN**

SCALE:  
1:100 & 1:50 AT A1

PROJECT NO: **C3637a**  
DRAWING NO: **E03**  
REVISION: **C**