



DETAIL A
MAIN KITCHEN FACADE ELEVATION
 SCALE 1:50

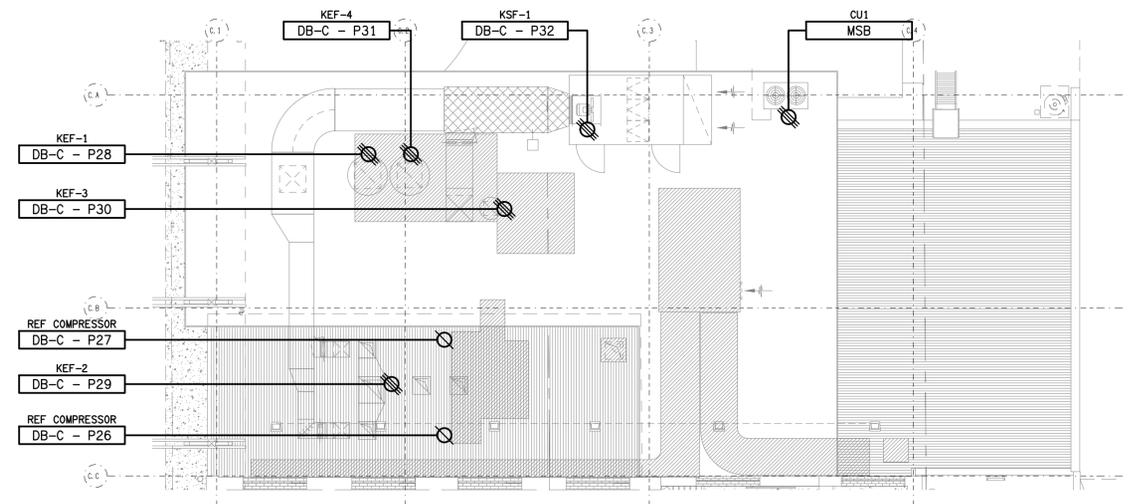

ROOF LEVEL
FLOOR PLAN
 SCALE 1:100

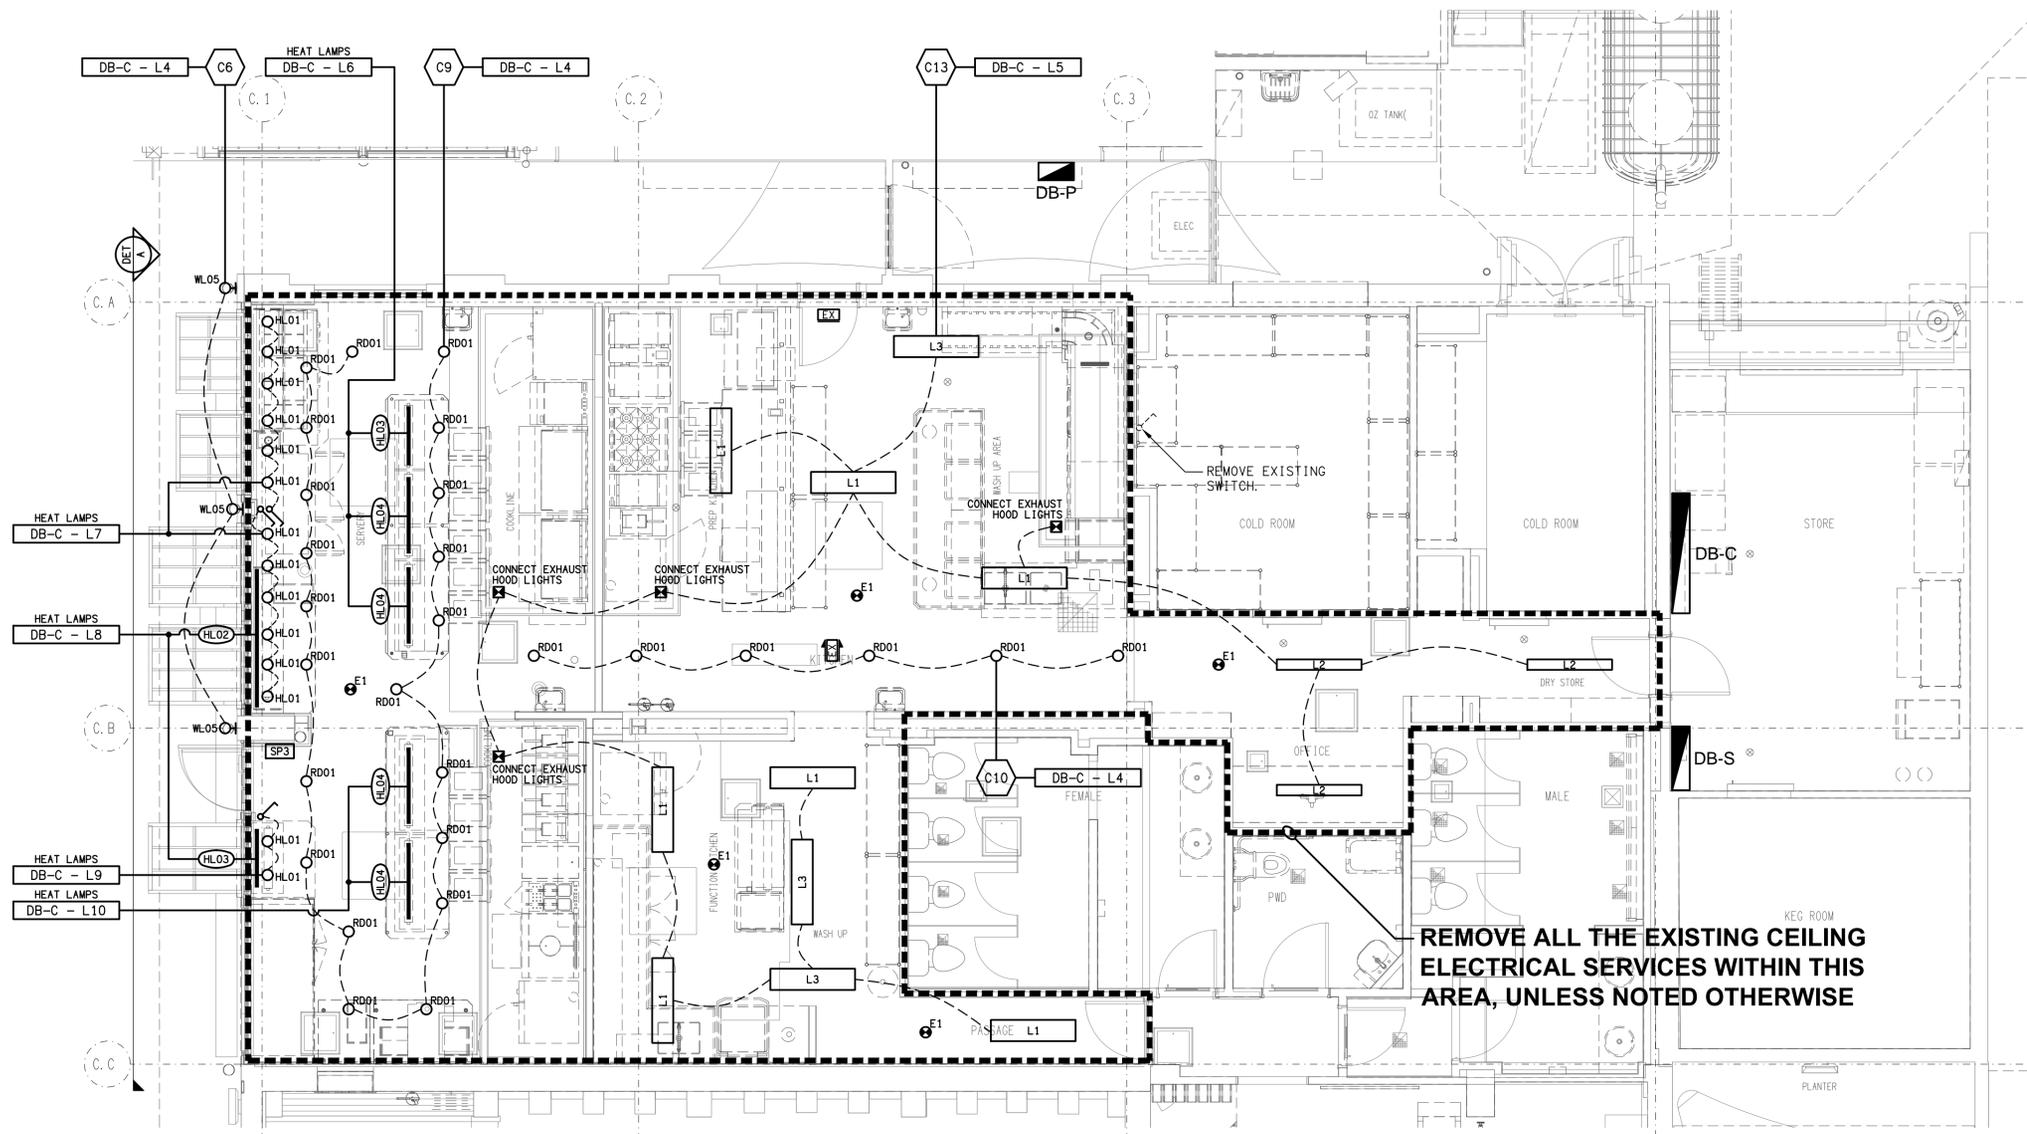

REMOVE ALL THE EXISTING CEILING ELECTRICAL SERVICES WITHIN THIS AREA, UNLESS NOTED OTHERWISE

ELECTRICAL DESIGN GROUP BRISBANE PTY LTD ACN 092 710 793 TRADING AS: ELECTRICAL DESIGN GROUP	THE COPYRIGHT OF THIS DRAWING REMAINS THE PROPERTY OF THE ELECTRICAL DESIGN GROUP. USE FIGURED DIMENSIONS IN PREFERENCE TO SCALE. ALL DIMENSIONS TO BE VERIFIED ONSITE.	ELECTRICAL DESIGN GROUP ELECTRICAL BUILDING SERVICES CONSULTANTS BRISBANE GOLD COAST P.O. Box 15, Sherwood Q.4075 Phone: (07) 3278 4375 Email: brisbane@edg.net.au Web: www.edg.net.au	PROJECT: BREAKFAST CREEK HOTEL - STAGE 2 2 KINGSFORD SMITH DRIVE, ALBION, QUEENSLAND	B TENDER REV: DESCRIPTION: 23/02/2026 DATE:
			DRAWING: ELECTRICAL SERVICES ZONE C MAIN KITCHEN REFLECTED CEILING PLAN SCALE: 1:50 UNO AT A1	PROJECT NO: C3674a