




**REFLECTED CEILING PLAN**  
MEZZANINE LEVEL  
SCALE 1:50

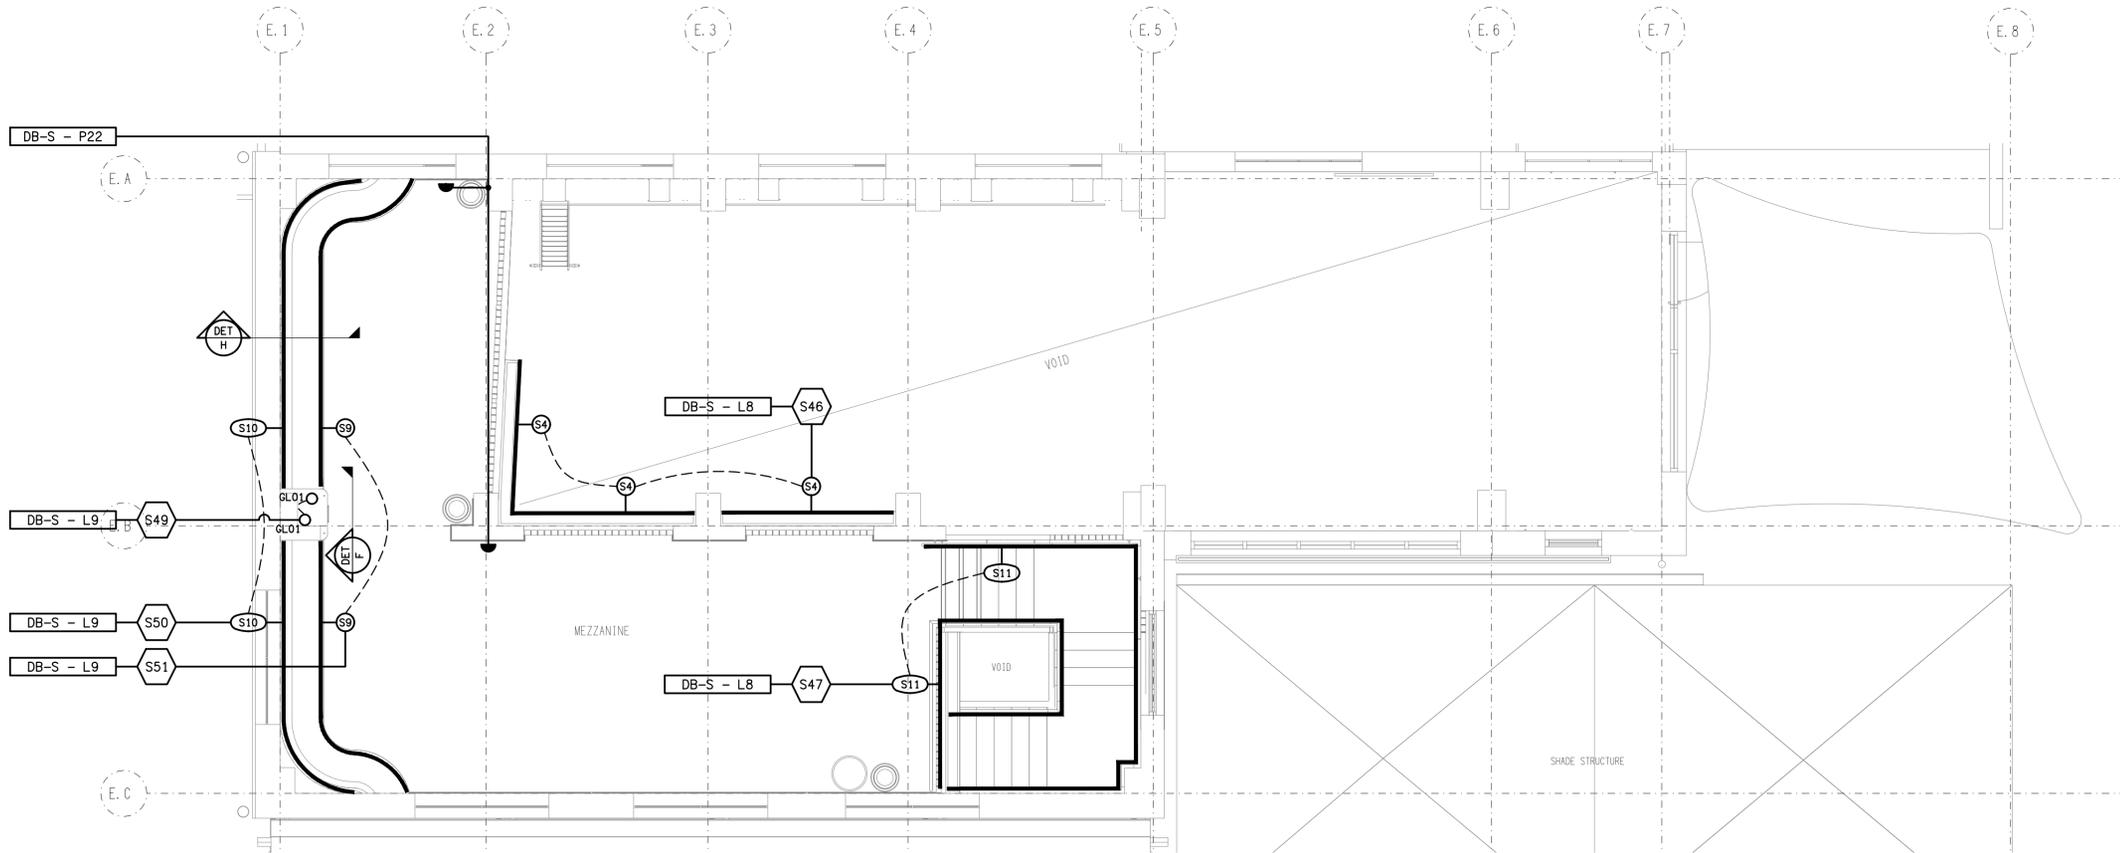


**FLOOR PLAN**  
MEZZANINE LEVEL  
SCALE 1:50

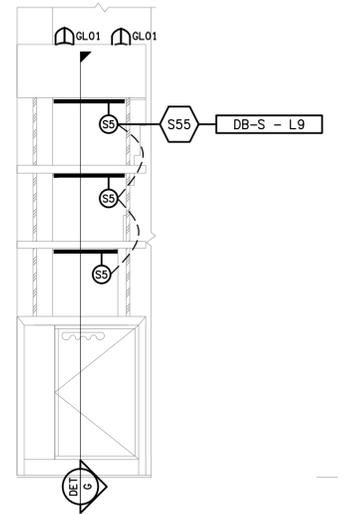

**DETAIL F**  
WAITERS STATION ELEVATION  
SCALE 1:20

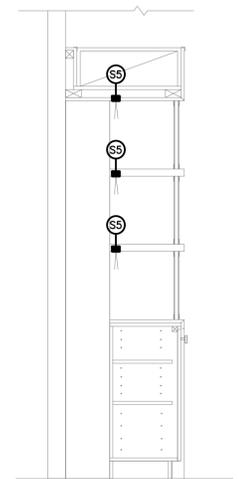

**DETAIL G**  
WAITERS STATION SECTION  
SCALE 1:20

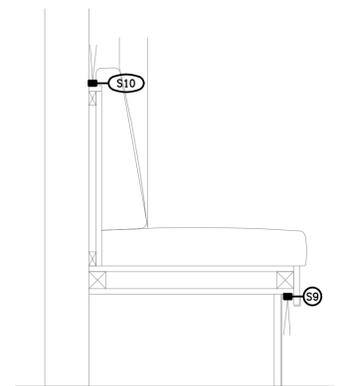

**DETAIL H**  
BANQUETTE SEAT SECTION  
SCALE 1:10

ELECTRICAL DESIGN GROUP BRISBANE  
PTY LTD  
ACN 092 710 793  
TRADING AS:  
ELECTRICAL DESIGN GROUP

THE COPYRIGHT OF THIS DRAWING  
REMAINS THE PROPERTY OF THE  
ELECTRICAL DESIGN GROUP.

USE FIGURED DIMENSIONS  
IN PREFERENCE TO SCALE.

ALL DIMENSIONS TO BE  
VERIFIED ONSITE.

**ELECTRICAL DESIGN GROUP**  
ELECTRICAL BUILDING SERVICES CONSULTANTS  
BRISBANE GOLD COAST

P.O. Box 15, Sherwood Q.4075  
Phone: (07) 3278 4375  
Email: brisbane@edg.net.au  
Web: www.edg.net.au

PROJECT:  
**BREAKFAST CREEK HOTEL - STAGE 2**

2 KINGSFORD SMITH DRIVE, ALBION, QUEENSLAND

B	TENDER	23/02/2026
REV.	DESCRIPTION:	DATE:

DRAWING:  
**ELECTRICAL SERVICES**  
ZONE E  
SUBSTATION BAR MEZZANINE PLANS

SCALE: 1:50 UNO	AT A1	PROJECT NO: <b>C3674a</b>	DRAWING NO: <b>EE03</b>	REVISION: <b>B</b>
--------------------	-------	------------------------------	----------------------------	-----------------------