

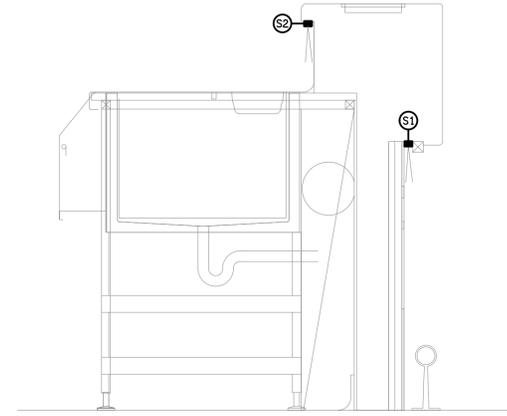



SUBSTATION BAR
LIGHTING PLAN
SCALE 1:50

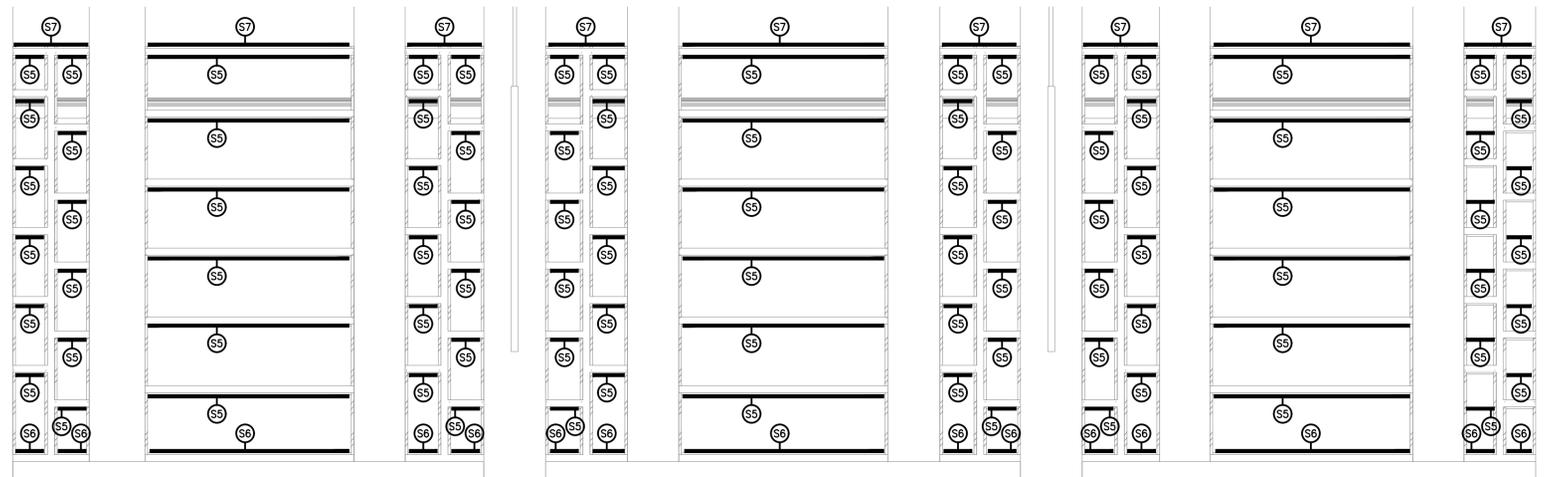


DETAIL A
COUNTER SECTION
SCALE 1:10

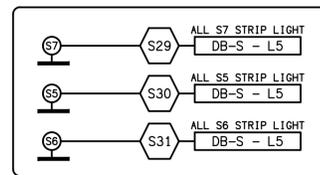

DETAIL B
REAR BAR WALL ELEVATION
SCALE 1:20

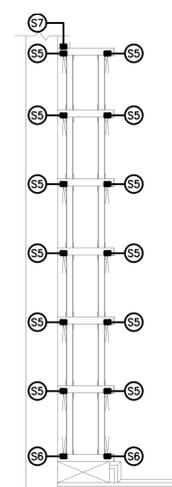

DETAIL C
REAR BAR WALL SECTION
SCALE 1:20

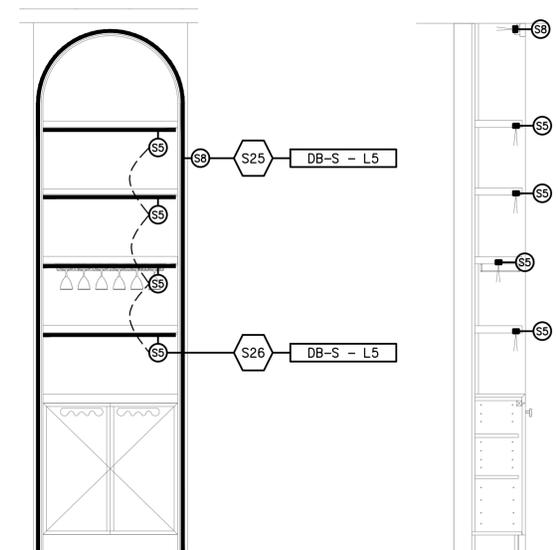

DETAIL D
WAITERS STATION ELEVATION
SCALE 1:20

DETAIL E
WAITERS STATION SECTION
SCALE 1:20

ELECTRICAL DESIGN GROUP BRISBANE
PTY LTD
ACN 092 710 793

TRADING AS:
ELECTRICAL DESIGN GROUP

THE COPYRIGHT OF THIS DRAWING
REMAINS THE PROPERTY OF THE
ELECTRICAL DESIGN GROUP.

USE FIGURED DIMENSIONS
IN PREFERENCE TO SCALE.

ALL DIMENSIONS TO BE
VERIFIED ONSITE.

ELECTRICAL DESIGN GROUP
ELECTRICAL BUILDING SERVICES CONSULTANTS
BRISBANE GOLD COAST

P.O. Box 15, Sherwood Q. 4075
Phone: (07) 3278 4375
Email: brisbane@edg.net.au
Web: www.edg.net.au

PROJECT:
BREAKFAST CREEK HOTEL - STAGE 2

2 KINGSFORD SMITH DRIVE, ALBION, QUEENSLAND

B	TENDER	23/02/2026
REV:	DESCRIPTION:	DATE:

DRAWING: ELECTRICAL SERVICES			
ZONE E			
SUBSTATION BAR LIGHTING PLAN & DETAILS			
SCALE: 1:50 UNO	PROJECT NO: C3674a	DRAWING NO: EE04	REVISION: B