


THE SIX SINGLE PHASE 20A EXISTING CIRCUITS WITHIN THIS AREA ARE TO BE RESUPPLIED FROM DB-E WITH NEW AS3000 COMPLIANT SWITCHGEAR.

REMOVE / RELOCATE ALL EXISTING ELECTRICAL SERVICES WITHIN THIS AREA.

FLOOR PLAN
STAGHORN BAR
SCALE 1:50

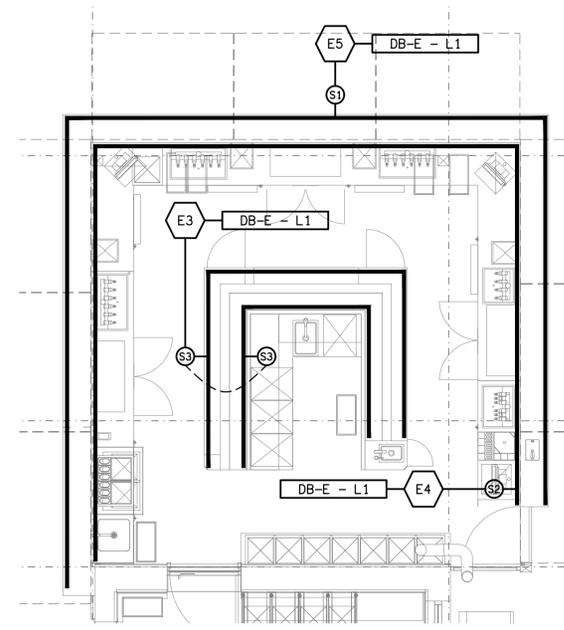

DETAIL
BAR LED STRIP LIGHTING PLAN
SCALE 1:50

ELECTRICAL DESIGN GROUP BRISBANE
PTY LTD
ACN 092 710 793
TRADING AS:
ELECTRICAL DESIGN GROUP

THE COPYRIGHT OF THIS DRAWING
REMAINS THE PROPERTY OF THE
ELECTRICAL DESIGN GROUP.
USE FIGURED DIMENSIONS
IN PREFERENCE TO SCALE.
ALL DIMENSIONS TO BE
VERIFIED ONSITE.

ELECTRICAL DESIGN GROUP
ELECTRICAL BUILDING SERVICES CONSULTANTS
BRISBANE GOLD COAST
P.O. Box 15, Sherwood Q. 4075
Phone: (07) 3278 4375
Email: brisbane@edg.net.au
Web: www.edg.net.au

PROJECT:
BREAKFAST CREEK HOTEL - STAGE 2
2 KINGSFORD SMITH DRIVE, ALBION, QUEENSLAND

B	TENDER	23/02/2026
REV:	DESCRIPTION:	DATE:
DRAWING: ELECTRICAL SERVICES ZONE H STAGHORN BAR FLOOR PLAN		
SCALE: 1:50 UNO	PROJECT NO: C3674a	DRAWING NO: EH01
AT A1	REVISION: B	