


ROOF LEVEL
PLANT DECK PLAN
SCALE 1:200

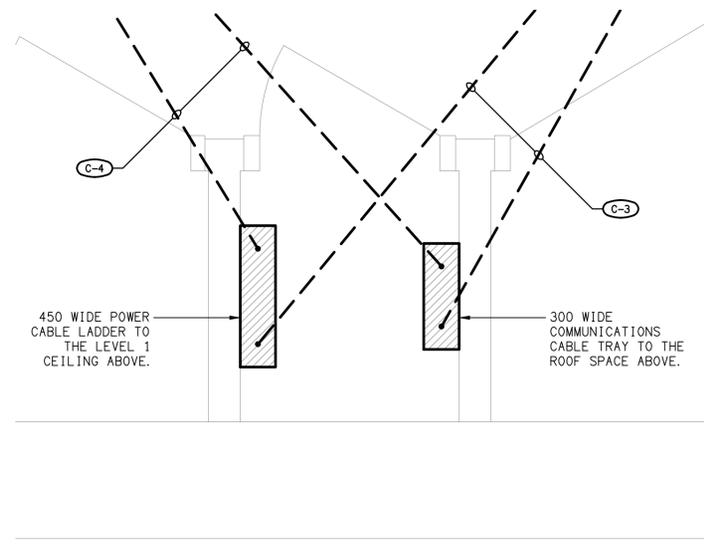

DETAIL A
ELECTRICAL RISER PLAN
SCALE 1:10

ELECTRICAL DESIGN GROUP BRISBANE
PTY LTD
ACN 092 710 793
TRADING AS:
ELECTRICAL DESIGN GROUP

THE COPYRIGHT OF THIS DRAWING
REMAINS THE PROPERTY OF THE
ELECTRICAL DESIGN GROUP.
USE FIGURED DIMENSIONS
IN PREFERENCE TO SCALE.
ALL DIMENSIONS TO BE
VERIFIED ONSITE.

ELECTRICAL DESIGN GROUP
ELECTRICAL BUILDING SERVICES CONSULTANTS
BRISBANE GOLD COAST
P.O. Box 15, Sherwood Q.4075
Phone: (07) 3278 4375
Email: brisbane@edg.net.au
Web: www.edg.net.au

PROJECT:
**KINGS CHRISTIAN COLLEGE
CHAMBERS FLAT, SENIOR SCHOOL CHA12**
38-112 ANZAC AVENUE, CHAMBERS FLAT

C	TENDER	16/02/2026
REV.	DESCRIPTION:	DATE:
DRAWING: ELECTRICAL SERVICES GROUND LEVEL FLOOR PLAN		
SCALE: 1:100 UNO	AT A1	PROJECT NO: C3474a
		DRAWING NO: E05
		REVISION: C