


SCHEMATIC
SWITCH PANEL SP1 / SP2 CONFIGURATION
NOT TO SCALE

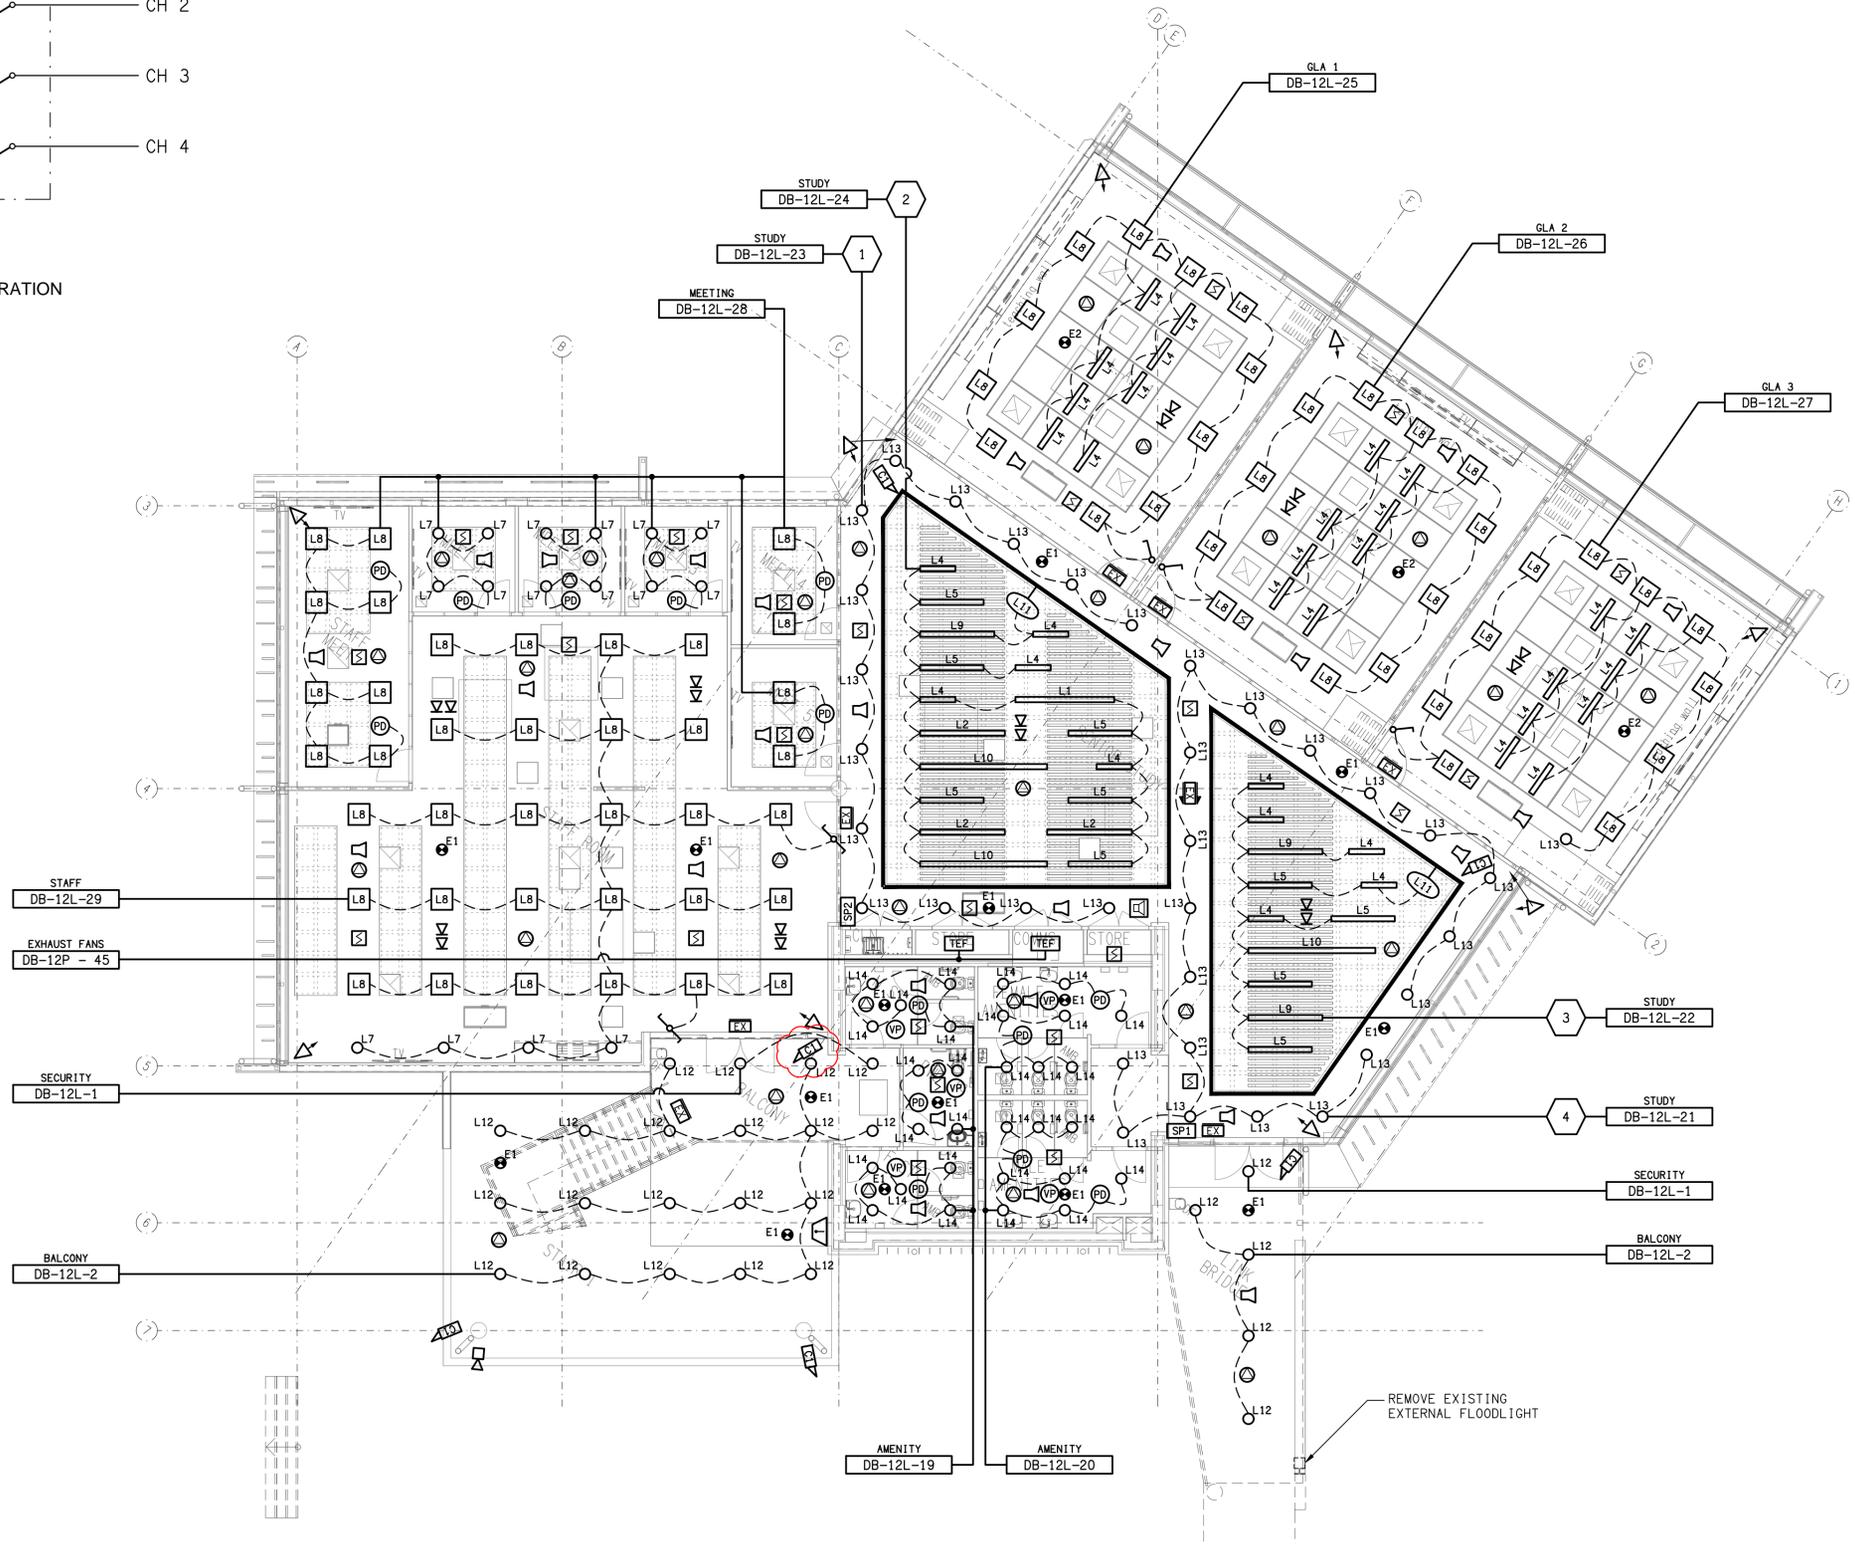

ELECTRICAL DESIGN GROUP BRISBANE PTY LTD ACN 092 710 793 TRADING AS: ELECTRICAL DESIGN GROUP	THE COPYRIGHT OF THIS DRAWING REMAINS THE PROPERTY OF THE ELECTRICAL DESIGN GROUP. USE FIGURED DIMENSIONS IN PREFERENCE TO SCALE. ALL DIMENSIONS TO BE VERIFIED ONSITE.	ELECTRICAL DESIGN GROUP ELECTRICAL BUILDING SERVICES CONSULTANTS BRISBANE GOLD COAST P.O. Box 15, Sherwood Q.4075 Phone: (07) 3278 4375 Email: brisbane@edg.net.au Web: www.edg.net.au	PROJECT: KINGS CHRISTIAN COLLEGE CHAMBERS FLAT, SENIOR SCHOOL CHA12 38-112 ANZAC AVENUE, CHAMBERS FLAT	C TENDER 16/02/2026 REV. DESCRIPTION: DATE: DRAWING: ELECTRICAL SERVICES LEVEL 2 REFLECTED CEILING PLAN SCALE: 1:100 AT A1	PROJECT NO: C3474a DRAWING NO: E10 REVISION: C