


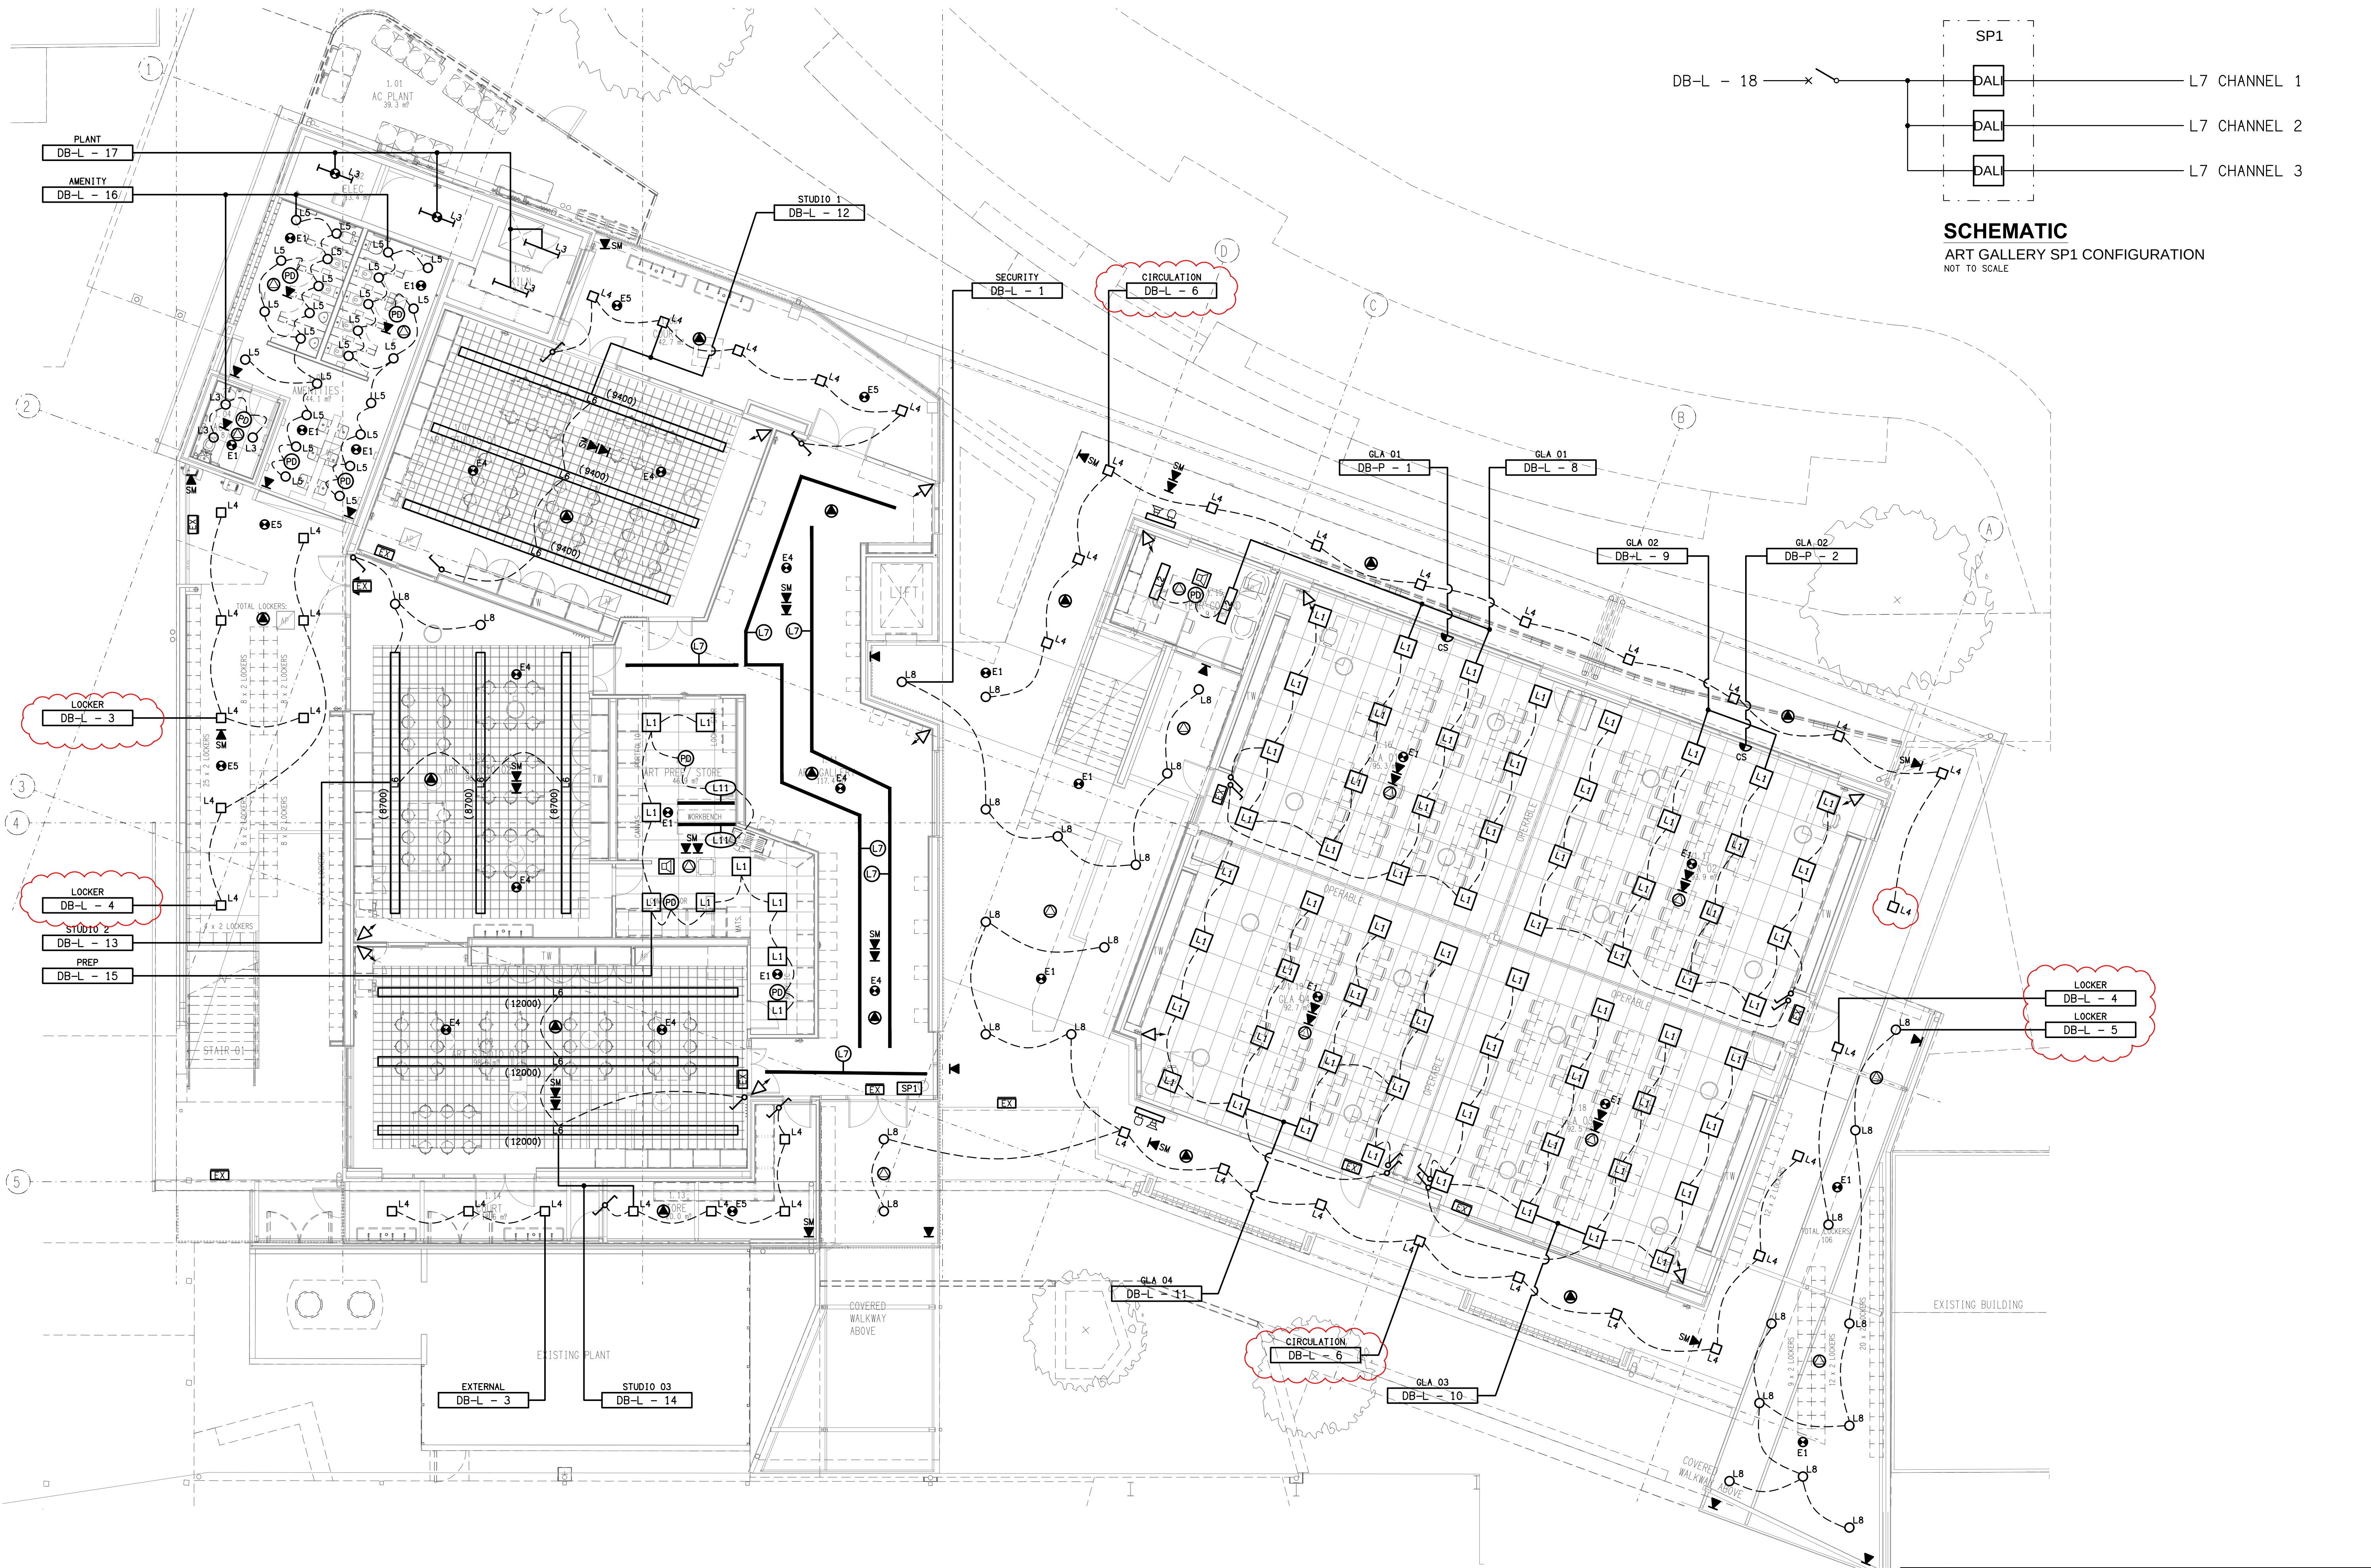

E	CONSTRUCTION	21/10/2026
REV.	DESCRIPTION:	DATE:
DRAWING:	ELECTRICAL SERVICES	
PROJECT NO:	GROUND LEVEL	
DRAWING NO:	REFLECTED CEILING PLAN	
SCALE:	PROJECT NO:	DRAWING NO:
1:100	AT A1	C3666a E05
REVISION:	E	

ELECTRICAL DESIGN GROUP BRISBANE
PTY LTD
ACN 092 710 793
TRADING AS:
ELECTRICAL DESIGN GROUP

THE COPYRIGHT OF THIS DRAWING
REMAINS THE PROPERTY OF THE
ELECTRICAL DESIGN GROUP.
USE FIGURED DIMENSIONS
IN PREFERENCE TO SCALE.
ALL DIMENSIONS TO BE
VERIFIED ONSITE.

ELECTRICAL DESIGN GROUP
ELECTRICAL BUILDING SERVICES CONSULTANTS
BRISBANE GOLD COAST
P.O. Box 15, Sherwood Q. 4075
Phone: (07) 3278 4375
Email: brisbane@edg.net.au
Web: www.edg.net.au

PROJECT:
ORMISTON COLLEGE
BUSINESS & ARTS PRECINCT
97 DUNDAS STREET WEST, ORMISTON