


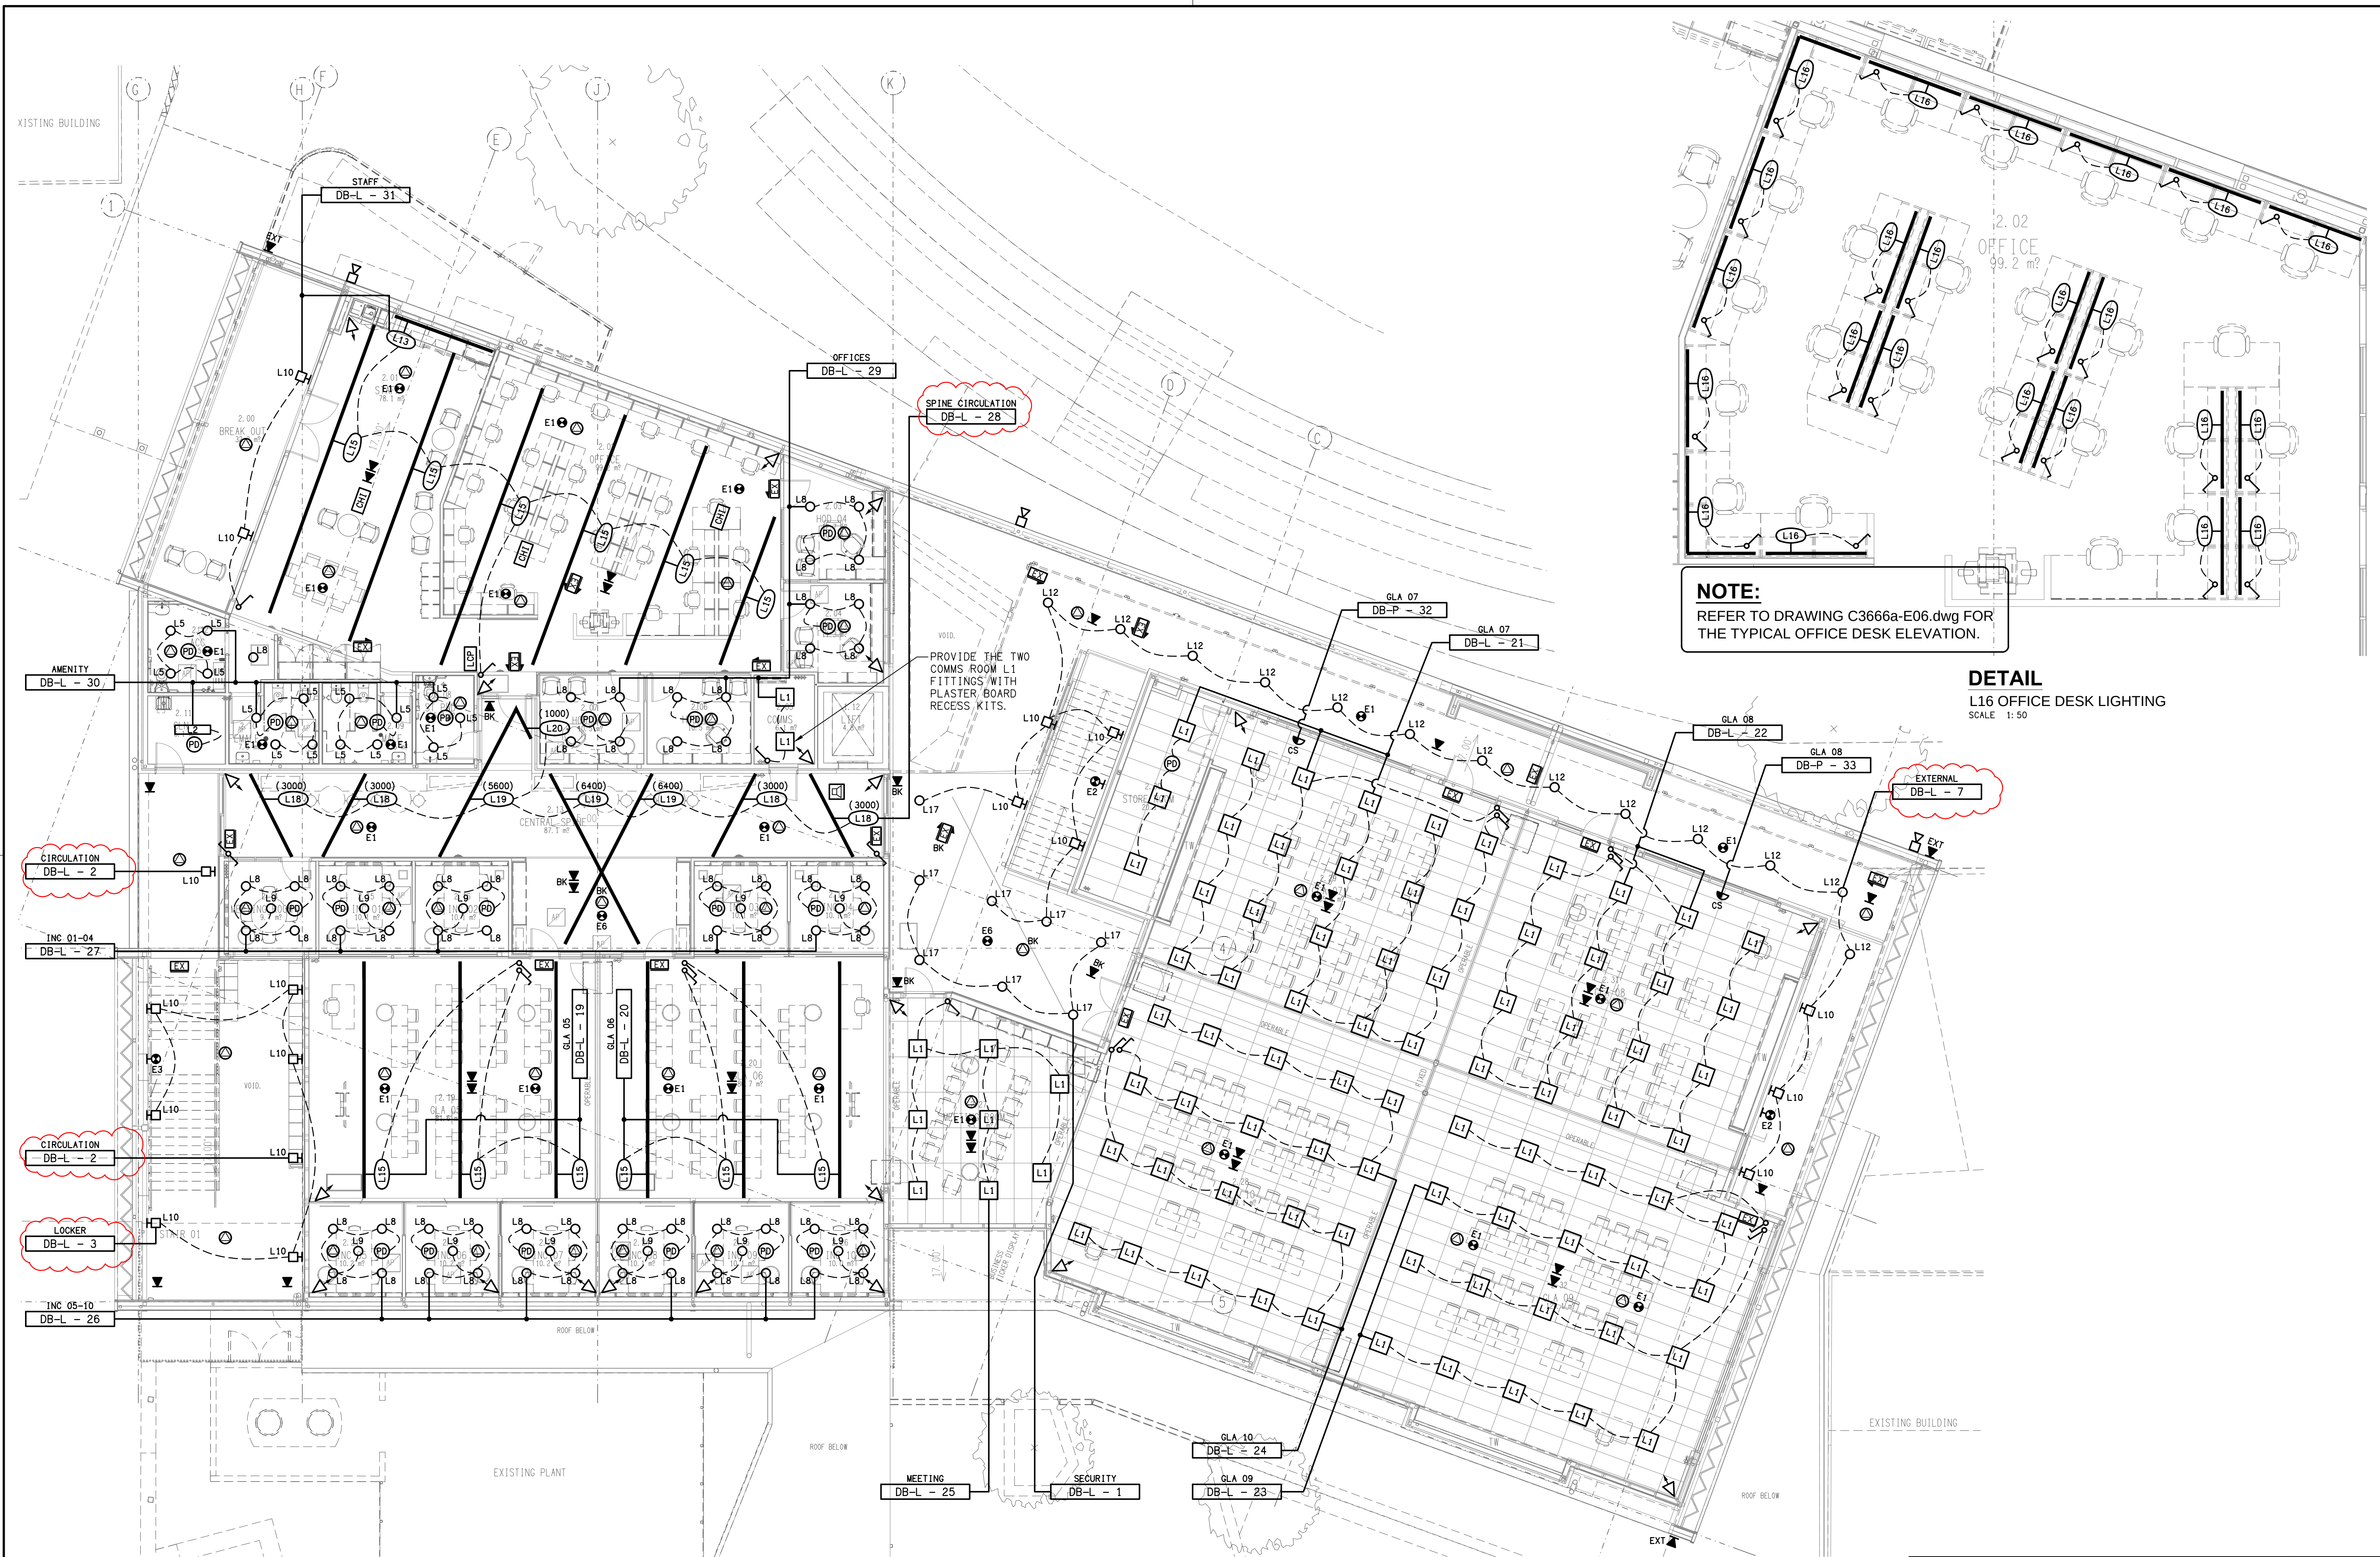

E	CONSTRUCTION	21/10/2026
REV:	DESCRIPTION:	DATE:
DRAWING:		
ELECTRICAL SERVICES LEVEL 1 REFLECTED CEILING PLAN		
SCALE:	PROJECT NO:	DRAWING NO:
1:100 UNO AT A1	C3666a	E07
		REVISION:
		E