


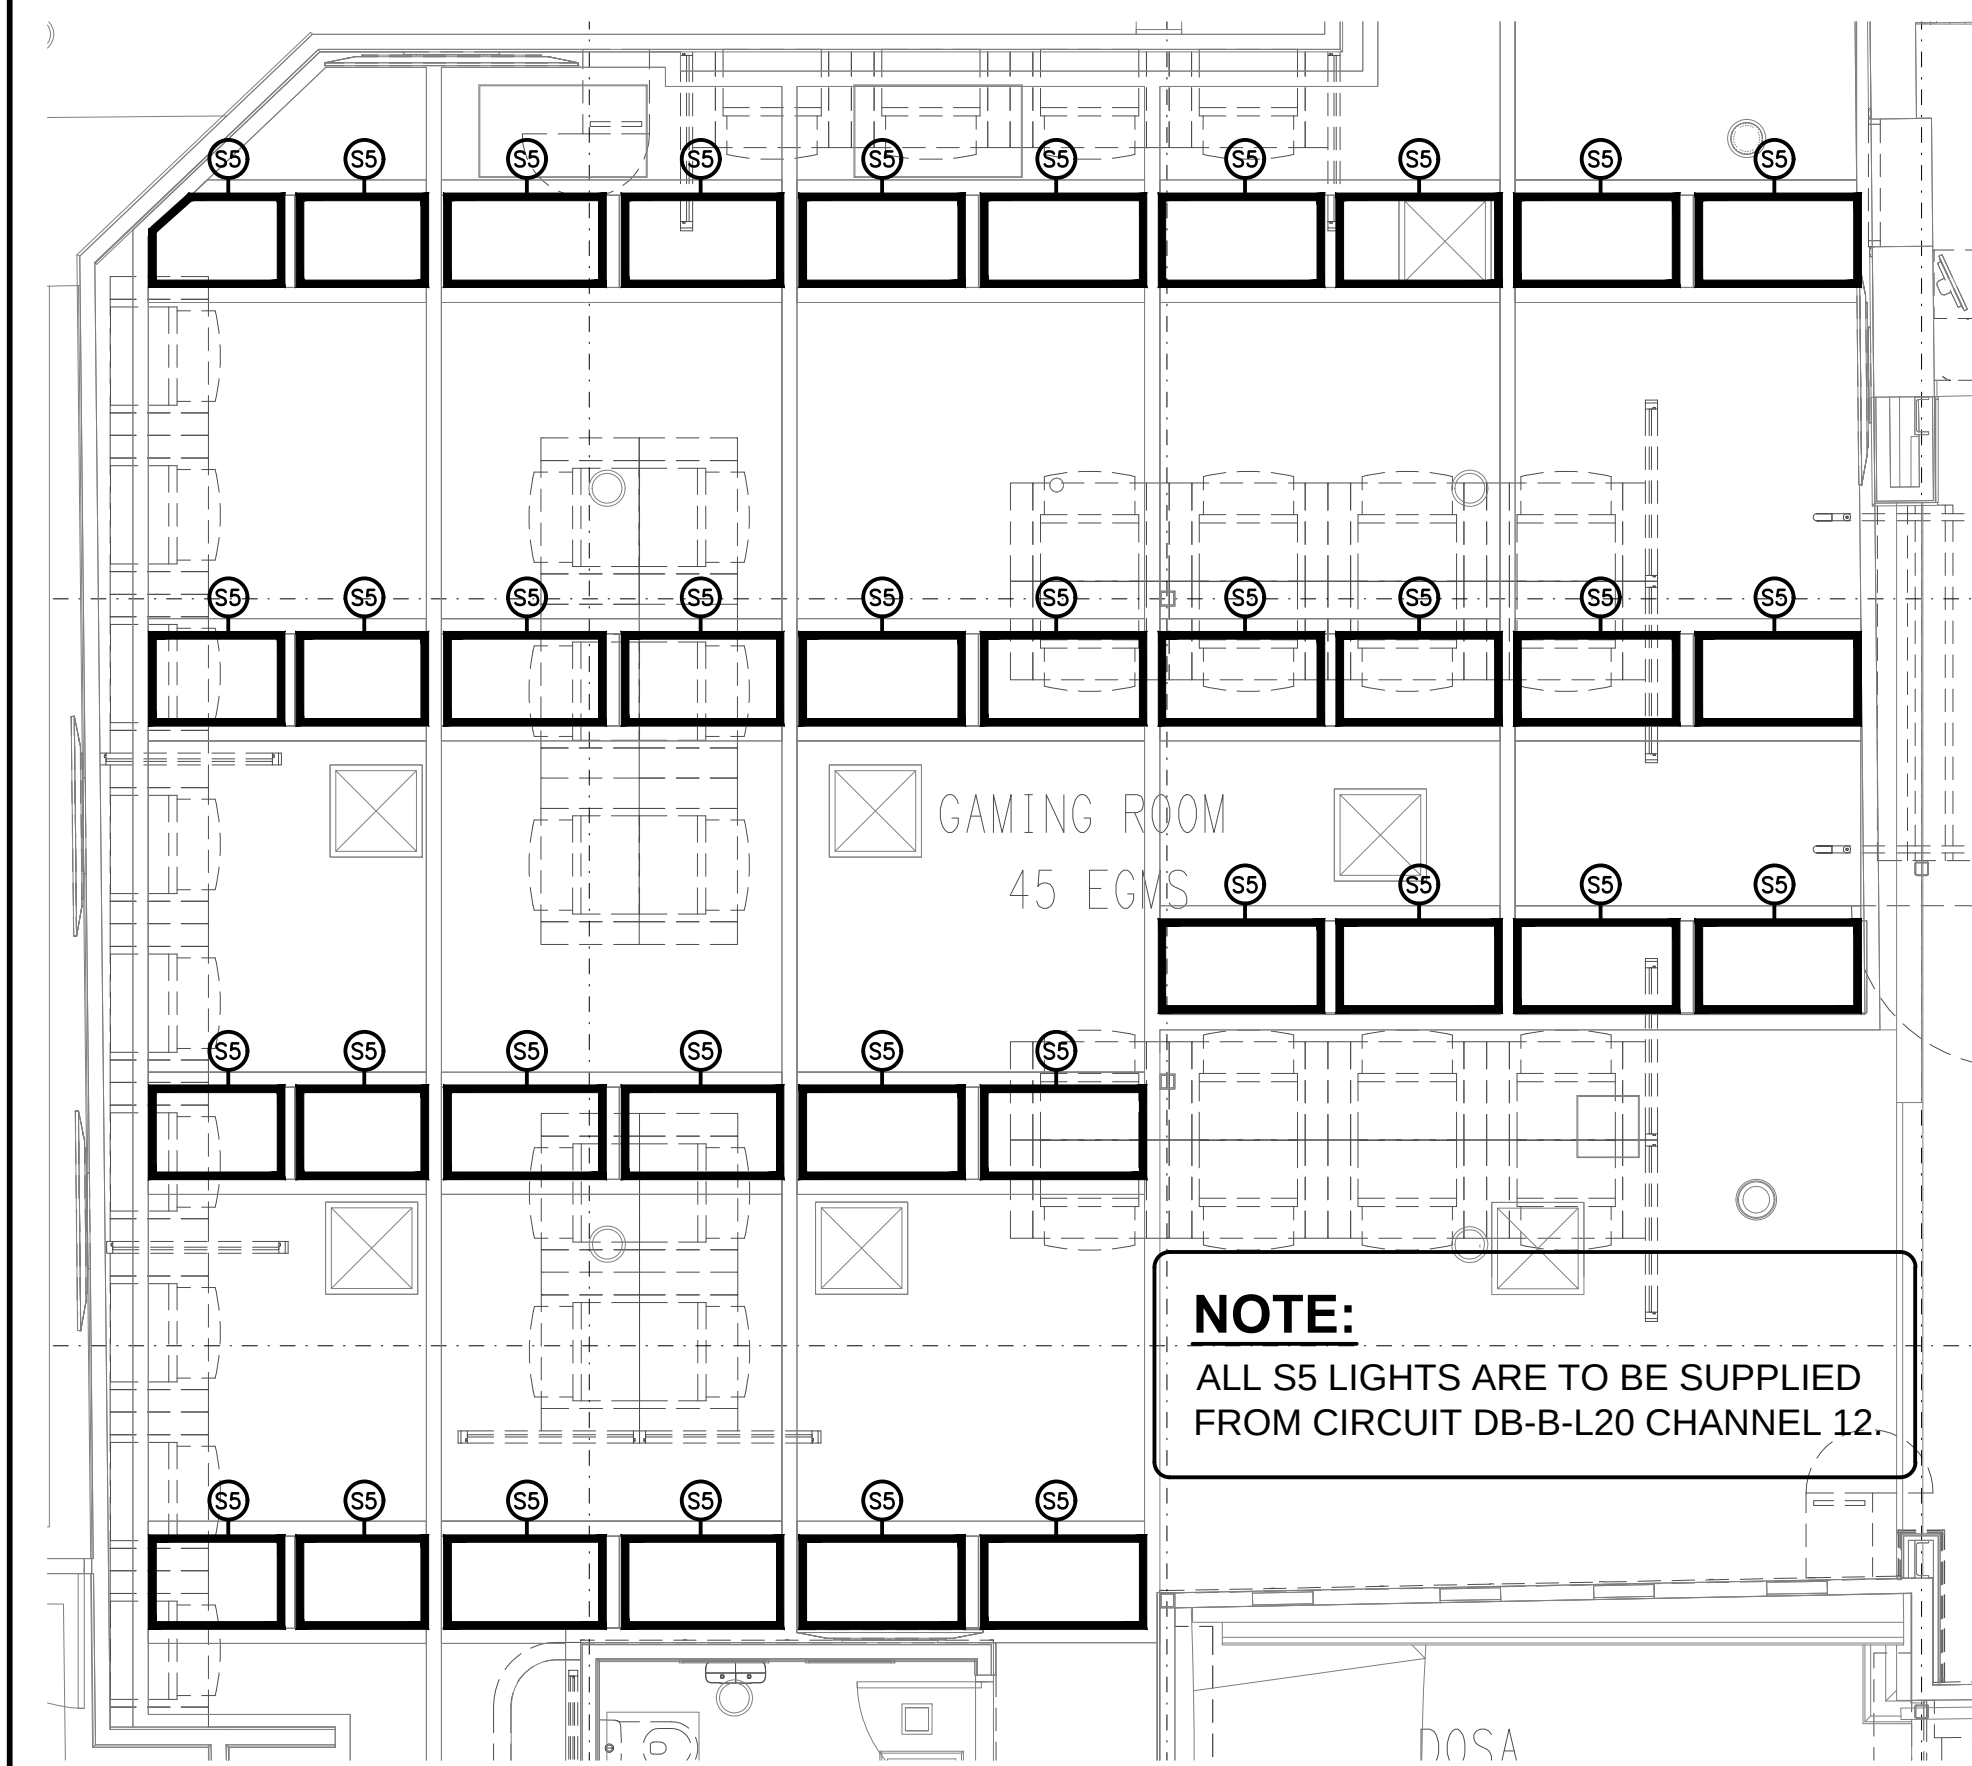

DETAIL A
GAMING ROOM S5 FEATURE LIGHTING PLAN
SCALE 1:50

NOTE:
ALL S5 LIGHTS ARE TO BE SUPPLIED FROM CIRCUIT DB-B-L20 CHANNEL 12.

NOTE:
REFER TO DRAWING C3685a-E05.dwg FOR THE ADDITIONAL JOINERY & WALL LIGHTING PLAN

EXISTING ELECTRICAL SERVICES WITHIN THIS DASH LINED AREA TO BE REMOVED, UNLESS NOTED OTHERWISE.

REMOVE THE EXISTING FESTOON LIGHTS IN THIS AREA AND REPLACE WITH THE NEW FS01. RESUPPLY ALL EXISTING REMAINING LIGHTS IN THIS AREA FROM CIRCUIT DB-B-L24 CHANNEL 15

NOTE:
RESUPPLY THE 4 F01 FANS FROM CIRCUIT DB-B-L7