

LEGEND


- ELECTRICAL SERVICES SWITCHBOARD.
- SWITCHBOARD / CONTROL PANEL NOT PROVIDED AS PART OF THE ELECTRICAL SUBCONTRACT.
- SINGLE POWER OUTLET.
- DOUBLE POWER OUTLET.
- EXISTING POWER OUTLET TO REMAIN AS IS, UNLESS NOTED OTHERWISE.
- SINGLE PHASE ISOLATOR.
- THREE PHASE ISOLATOR.
- SIGNAGE CONNECTION.
- JUNCTION BOX AS NOTED.
- GOLF SIMULATOR 40 DIA POWER CONDUIT.
- LIGHTING CONTROL SWITCH PANEL, TYPE AS NOTED.
- ONE-WAY LIGHT SWITCH.
- TWO-WAY LIGHT SWITCH.
- CIRCUIT LINE.
- SWITCH LINE.
- POWER CIRCUIT DESIGNATION.
DENOTES DB AND CIRCUIT.
- LIGHTING CONTROL CHANNEL REFERENCE.
- ELECTRICAL EQUIPMENT AS NOTED.
- RJ45 COMMUNICATIONS OUTLET.
- MANUAL CALL POINT.
- SMOKE DETECTOR, BLACK.
- SMOKE DETECTOR, WHITE.
- FIRE EVACUATION SPEAKER, BLACK.
- FIRE EVACUATION SPEAKER, WHITE.
- GSC GOLF SIMULATOR COMPUTER.
- GSH GOLF SIMULATOR HITTING SCREEN.
- GSP GOLF SIMULATOR PROJECTOR.
- ION GOLF SIMULATOR ION CAMERA.
- CLK GOLF SIMULATOR CLOCK.
- REFER TO DETAIL NOTED FOR THE AREA SHOWN HATCHED.
ADDITIONAL OUTLETS & FITTINGS MAY BE SHOWN ON DETAIL.
- E1: GENERAL RECESSED LED EMERGENCY LIGHT, BLACK.
- E2: GENERAL RECESSED LED EMERGENCY LIGHT, WHITE.
- EX: EMERGENCY LED EXIT LIGHT, BLACK.
- Lx: LIGHT FITTING C/W NON-MAINTAINED EMERGENCY BATTERY PACK.
TYPE AS NOTED.
- L1: 600 x 300 LED FLAT PANEL LIGHT.
- L2: 600 x 600 LED FLAT PANEL LIGHT.
- FS01: DOSA FESTOON LIGHTING.

LEGEND

- PD01: DECORATIVE LIGHT PENDANT.
- PD02: DECORATIVE PENDANT.
- PD03: DECORATIVE PENDANT.
- PD04: DECORATIVE PENDANT.
- RD01: RECESSED DOWNLIGHT.
- RD02: RECESSED DOWNLIGHT.
- RD03: RECESSED DOWNLIGHT.
- RD04: RECESSED DOWNLIGHT.
- RDE: EXISTING RECESSED DOWNLIGHT TO REMAIN AS IS.
UNLESS NOTED OTHERWISE.
- WL01: DECORATIVE WALL LIGHT.
- WL02: DECORATIVE WALL LIGHT.
- S1: BAR COUNTER LED STRIP LIGHT.
- S2: BAR REAR SHELIVING LED STRIP LIGHT.
- S3: NOT REQUIRED.
- S4: SPORTS BAR FEATURE JOINERY LED STRIP LIGHT.
- S5: BAR ENTRY SHELIVING LED STRIP LIGHT.


NOTE

ALL ELECTRICAL PENETRATIONS THROUGH THE ROOF SHEETING ARE TO BE IN LINE WITH THE STRUCTURAL OR MECHANICAL SERVICES PENETRATIONS TO AVOID DEDICATED FLASHINGS FOR THE ELECTRICAL SERVICES.

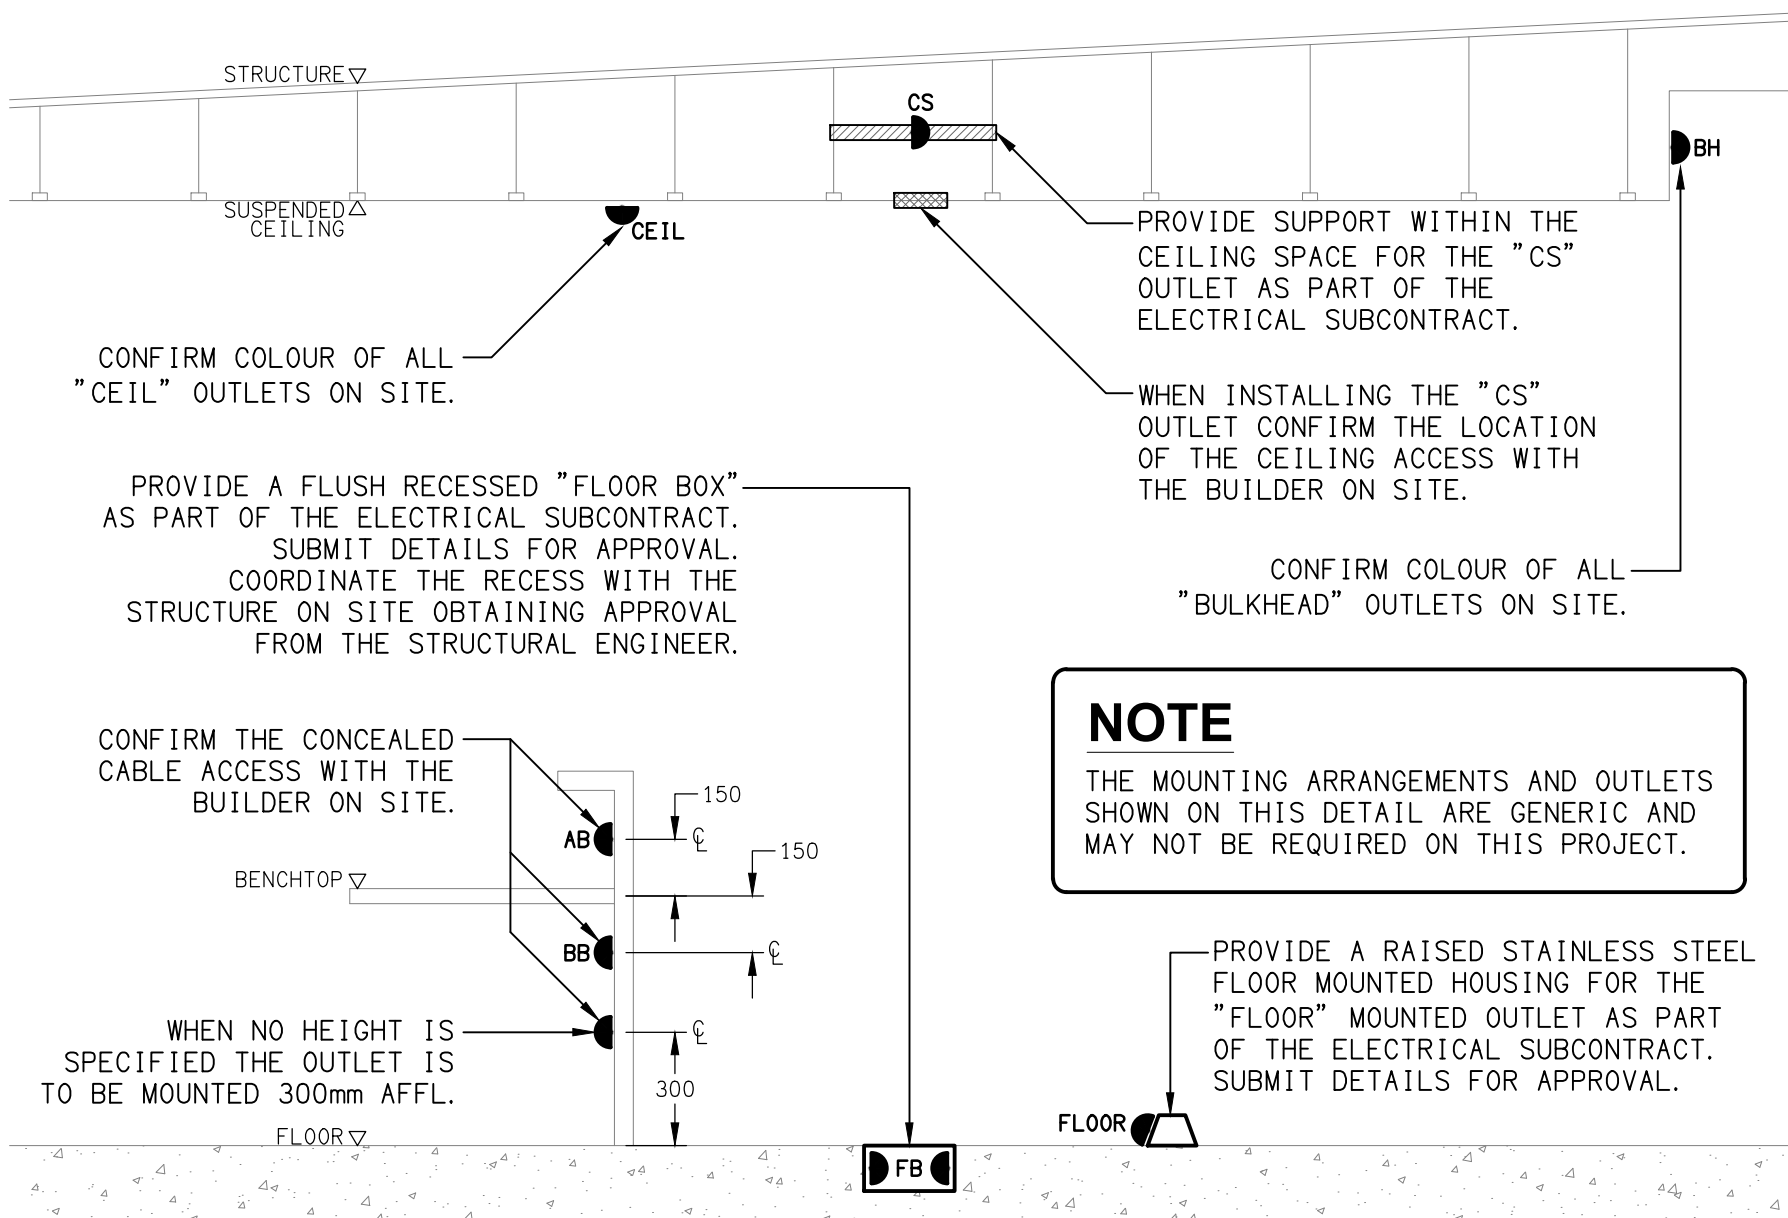

DETAIL

TYPICAL OUTLET MOUNTINGS
NOT TO SCALE

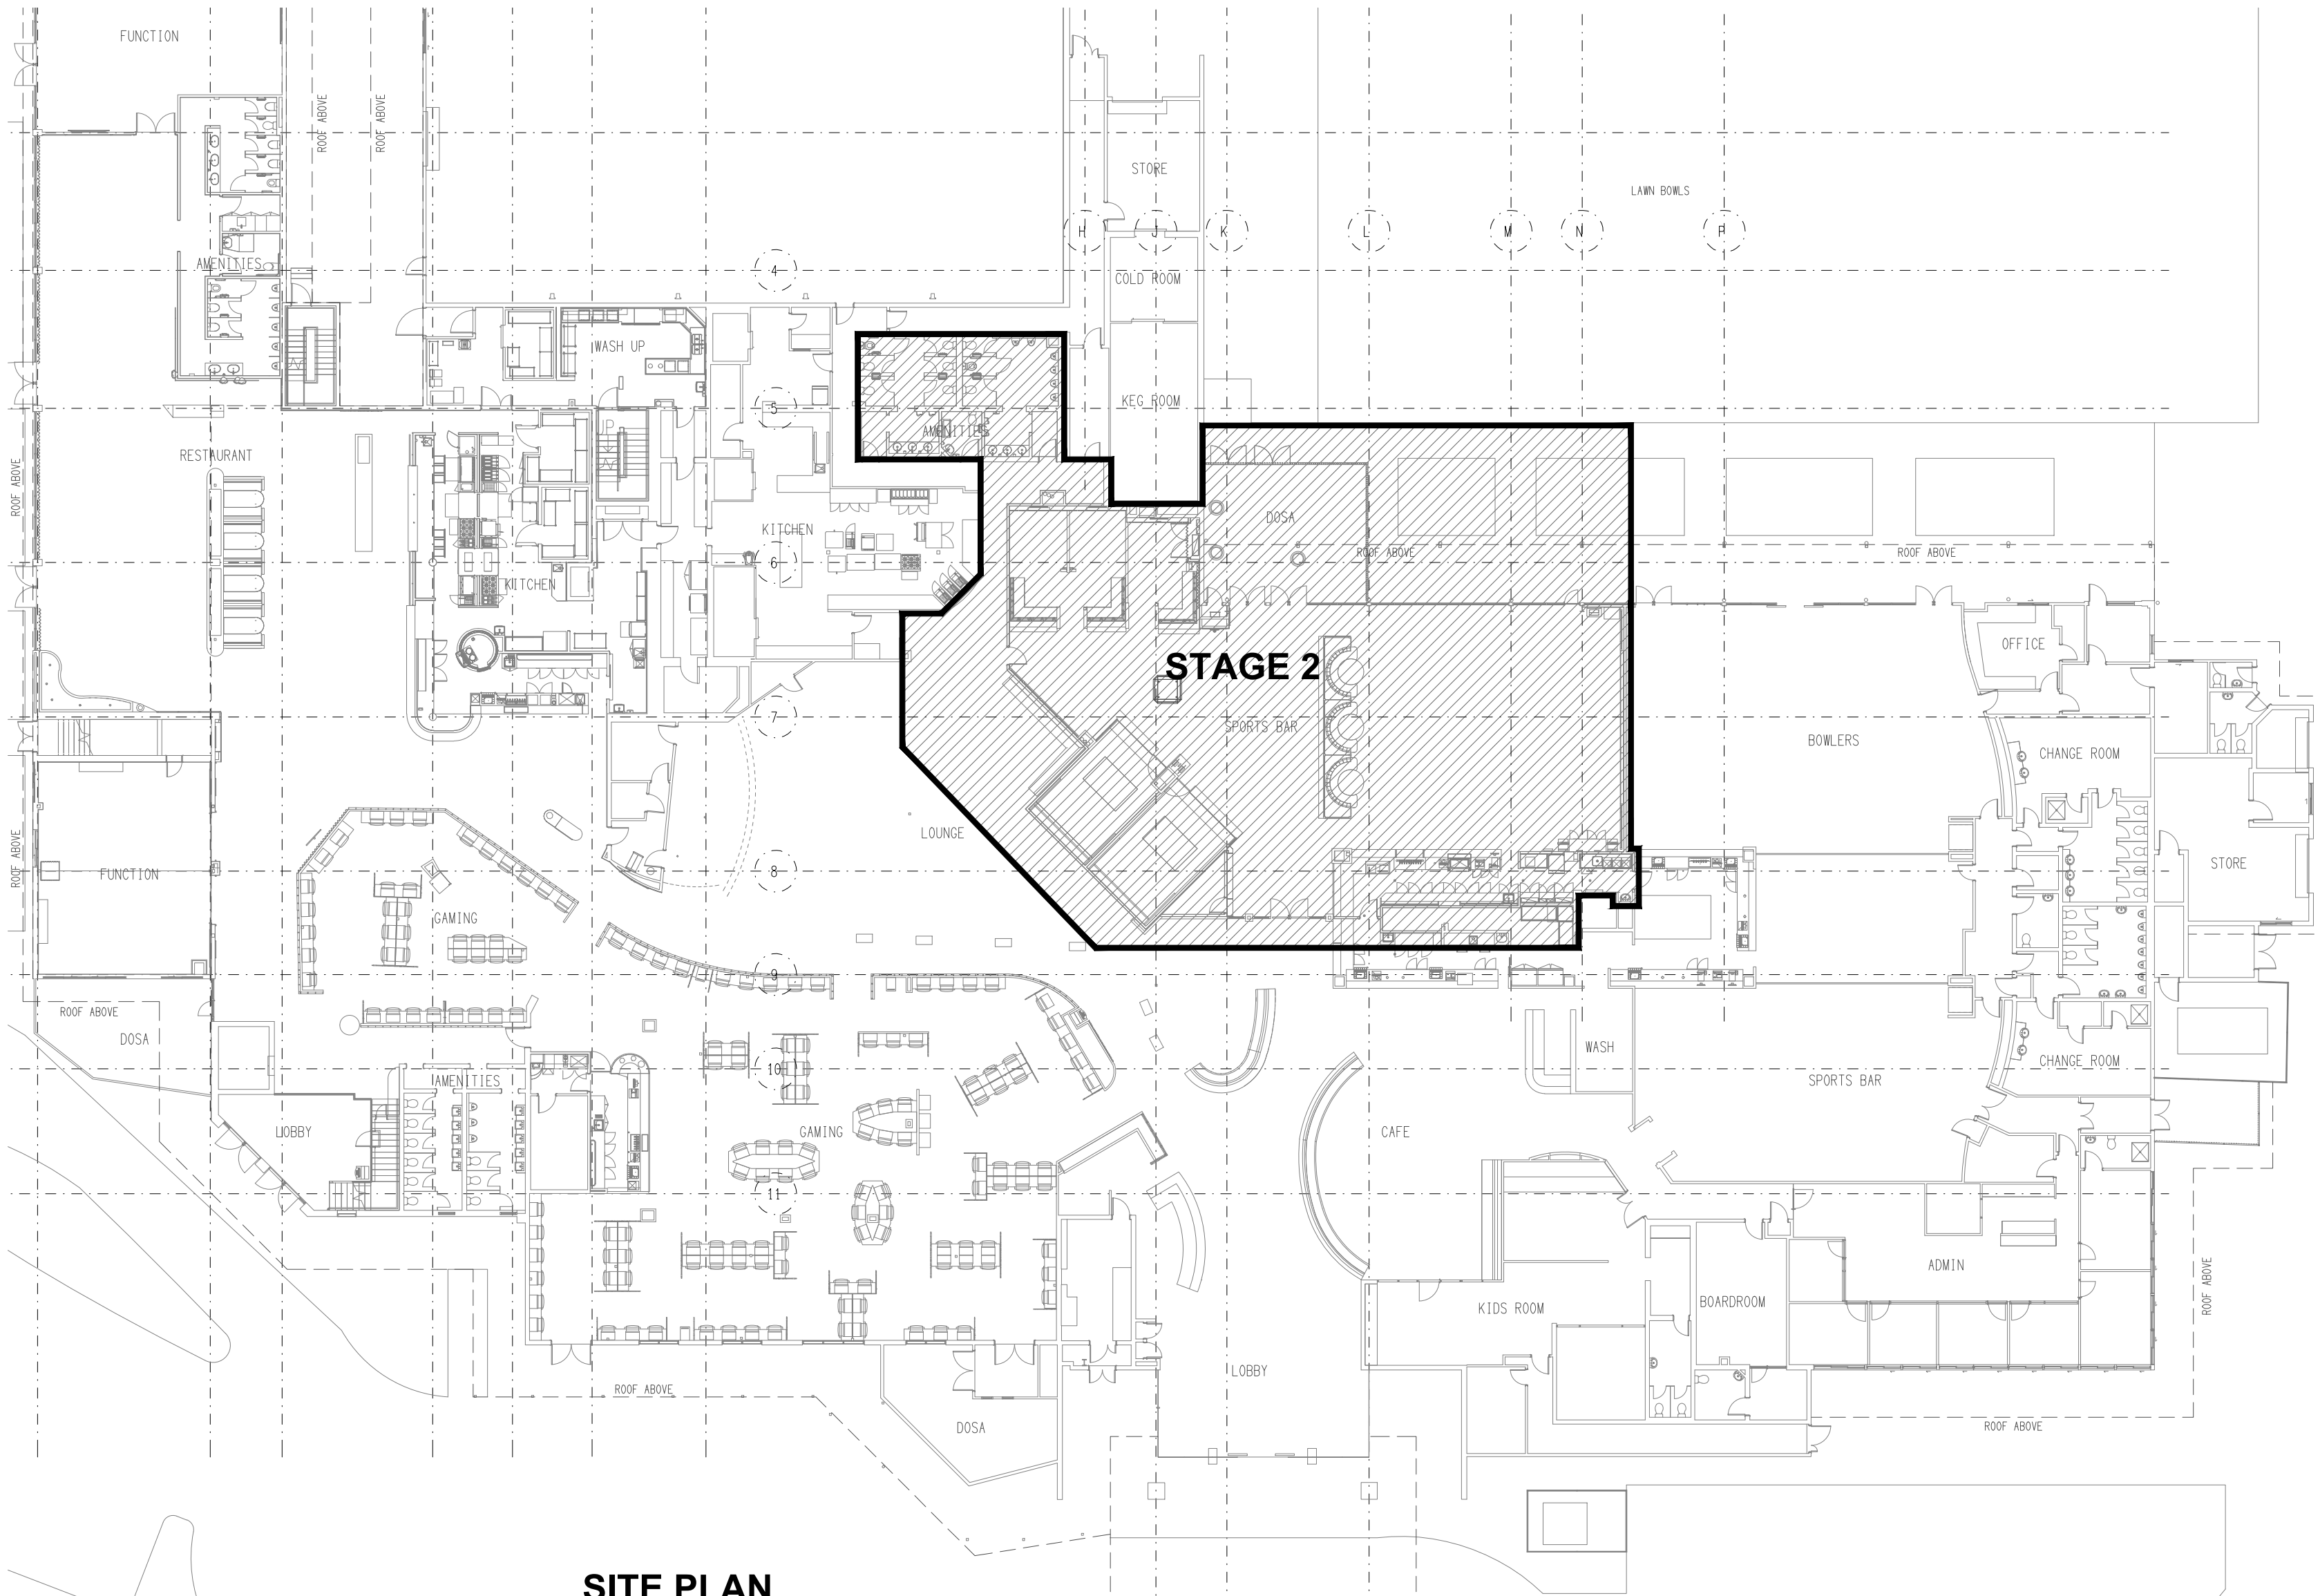

SITE PLAN

EXTENT OF STAGE 2 REFURBISHMENT
SCALE 1: 250

ELECTRICAL DESIGN GROUP BRISBANE PTY LTD ACN 092 710 793 TRADING AS: ELECTRICAL DESIGN GROUP	THE COPYRIGHT OF THIS DRAWING REMAINS THE PROPERTY OF THE ELECTRICAL DESIGN GROUP. USE FIGURED DIMENSIONS IN PREFERENCE TO SCALE. ALL DIMENSIONS TO BE VERIFIED ONSITE.	ELECTRICAL DESIGN GROUP ELECTRICAL BUILDING SERVICES CONSULTANTS BRISBANE GOLD COAST P.O.Box 15, Sherwood Qld 4075 Phone: 0418 893 338 Email: brisbane@edg.net.au Web: www.edg.net.au	PROJECT: REDLANDS SPORTING CLUB - STAGE 2 ANSON ROAD, WELLINGTON POINT, QUEENSLAND	B TENDER 20/10/2026 REV: DESCRIPTION: DATE:	
				DRAWING: ELECTRICAL SERVICES LEGEND & DETAILS SCALE: NOT TO SCALE AT A1	PROJECT NO: C3763a DRAWING NO: E01 REVISION: B