


LEGEND

- ELECTRICAL SERVICES SWITCHBOARD.
- SWITCHBOARD / CONTROL PANEL NOT PROVIDED AS PART OF THE ELECTRICAL SUBCONTRACT.
- EXISTING POWER OUTLET AS NOTED.
- SINGLE POWER OUTLET.
- DOUBLE POWER OUTLET.
- TV POWER OUTLET, POSITION CONFIRMED WITH AV CONTRACTOR.
- SIGNAGE CONNECTION.
- SINGLE PHASE ISOLATOR.
- THREE PHASE ISOLATOR.
- LIGHTING CONTROL SWITCH PANEL, TYPE x.
- CIRCUIT LINE.
- SWITCH LINE.
- POWER CIRCUIT DESIGNATION. DENOTES DB AND CIRCUIT.
- LIGHTING CONTROL CHANNEL REFERENCE.
- ELECTRICAL EQUIPMENT AS NOTED.
- REFER TO DETAIL NOTED FOR THE AREA SHOWN HATCHED. ADDITIONAL OUTLETS & FITTINGS MAY BE SHOWN ON DETAIL.
- E1: GENERAL CEILING RECESSED LED EMERGENCY LIGHT, WHITE.
- EX: EMERGENCY LED EXIT LIGHT, WHITE.
- FS01: DECK DALI DIMMABLE BLACK FESTOON LIGHTING.
- H01: EXISTING EXTERNAL CEILING HEATER AND CONTROL TO BE RETAINED.
- L01: BISTRO PENDANT.
- L02: BISTRO PENDANT.
- L03: GAMING BAR COUNTER PENDANT.
- L04: GAMING ROOM WALL LIGHT.
- L05: SPORTS BAR WALL LIGHT.
- L06: TERRACE PENDANT.
- L07: TERRACE PENDANT.
- L08: MAIN ENTRY WALL LIGHT.
- L09: DALI DIMMABLE RECESSED DOWNLIGHT WHITE.
- S1: GAMING BAR REAR WALL SHELIVING DALI DIMMABLE LED STRIP LIGHT.
- S2: BAR COUNTER DALI DIMMABLE LED STRIP LIGHT.
- S3: BAR REAR WALL SHELIVING DALI DIMMABLE LED STRIP LIGHT.
- S4: SPORTS BAR REAR WALL DALI DIMMABLE LED STRIP LIGHT.
- S5: SPORTS BAR OVERHEAD GANTRY DALI DIMMABLE LED STRIP LIGHT.
- S6: BANQUETTE SEATING DALI DIMMABLE LED STRIP LIGHT.
- S7: TV SURROUND DALI DIMMABLE LED STRIP LIGHT.
- S8: DISPLAY SHELIVING DALI DIMMABLE LED STRIP LIGHT.
- S9: BAR REAR WALL DALI DIMMABLE LED STRIP LIGHT.

LEGEND


- S10: BISTRO FEATURE CEILING PELMET DALI DIMMABLE LED STRIP LIGHT.
- S11: GAMING FEATURE CEILING PELMET DALI DIMMABLE LED STRIP LIGHT.
- S12: TAB PELMET DALI DIMMABLE LED STRIP LIGHT.
- B1: PALM TREE BUD LIGHTS.
- G1: GAMING BASE LED STRIP LIGHT BY GAMING ELECTRICIAN.
- G2: GAMING SCREEN LED STRIP LIGHT BY GAMING ELECTRICIAN.

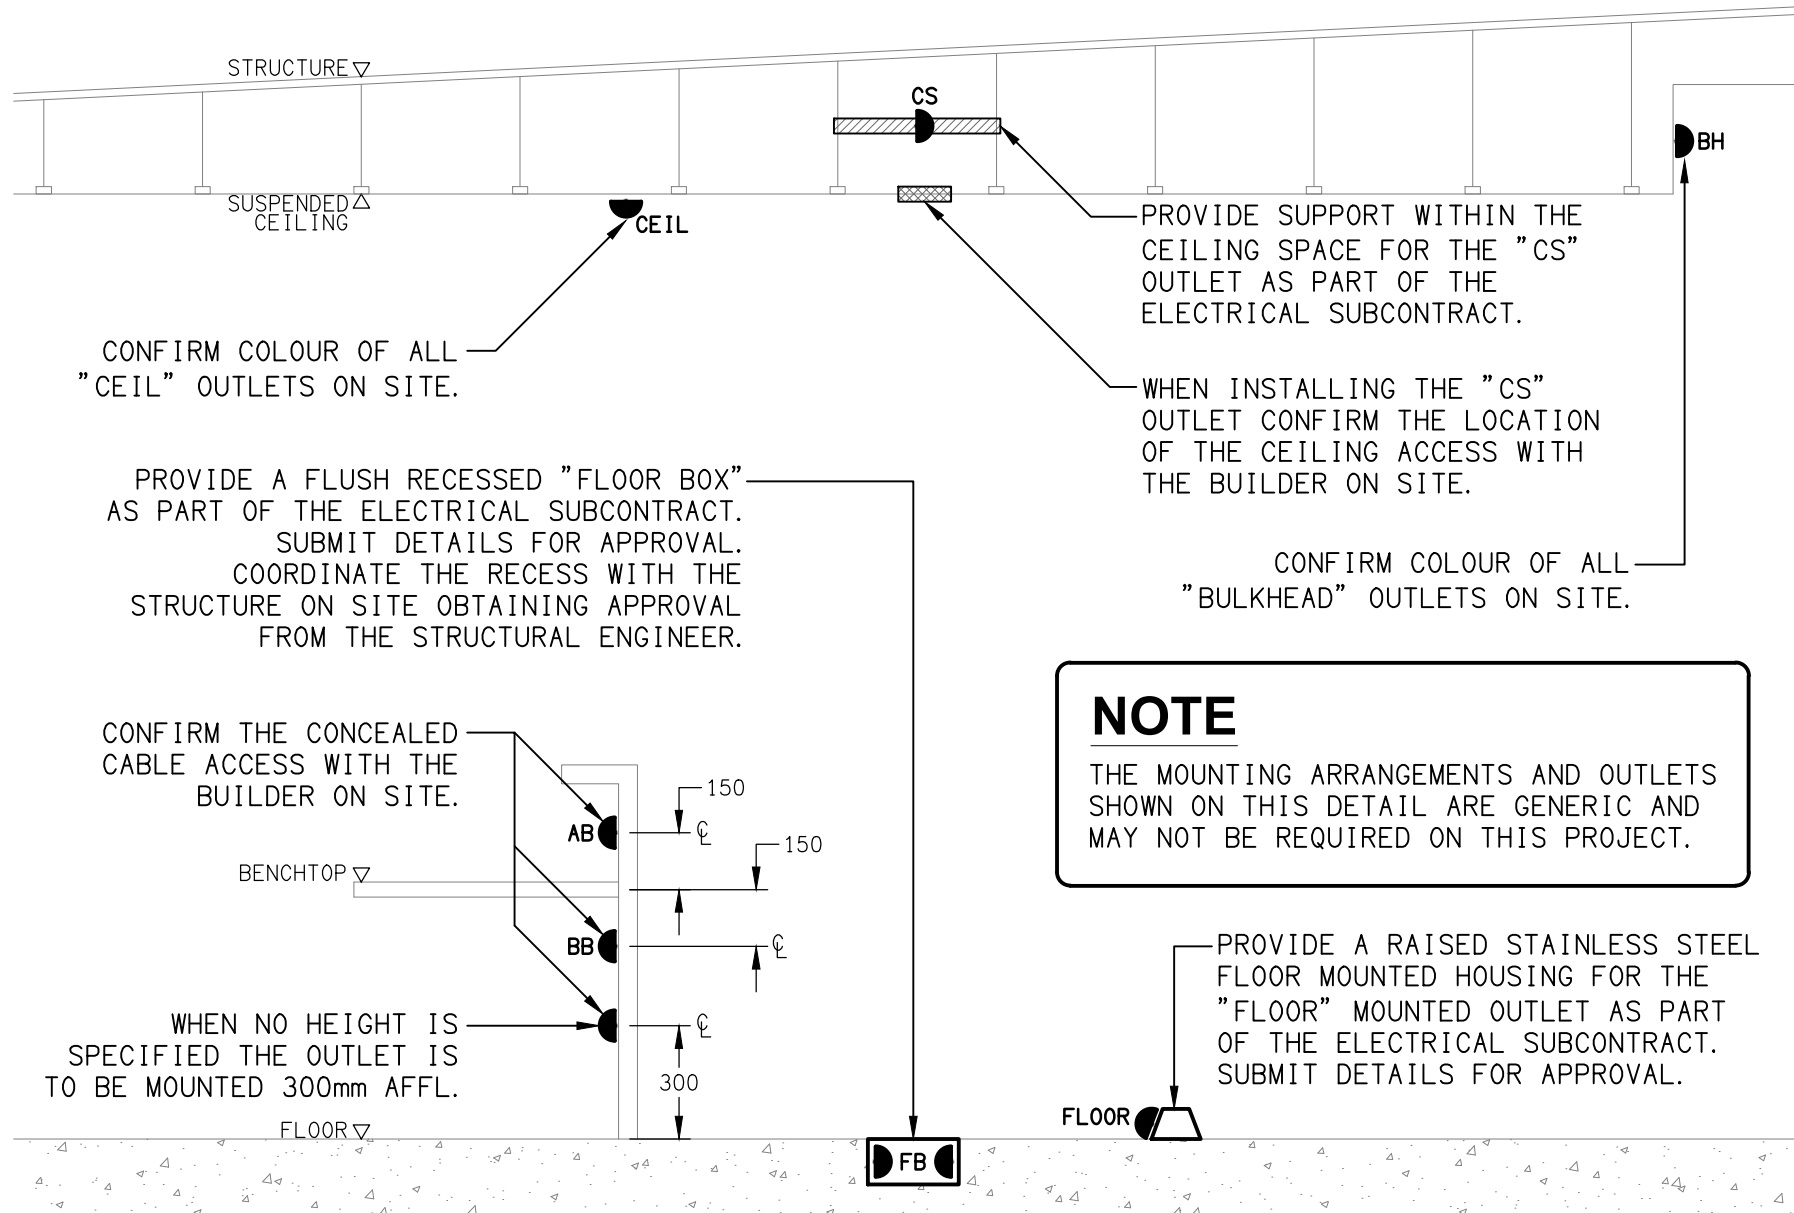

DETAIL  
TYPICAL OUTLET MOUNTINGS  
NOT TO SCALE

EQUIPMENT:


- TEST - TEST PUSH BUTTON MOUNTED ON THE DISTRIBUTION BOARD ESCUTCHEON.
- RESET - RESET PUSH BUTTON MOUNTED ON THE DISTRIBUTION BOARD ESCUTCHEON.
- LAMP - AMBER TEST INDICATING LAMP MOUNTED ON THE DISTRIBUTION BOARD ESCUTCHEON.
- Ta - ADJUSTABLE 0-3 HOUR TIMED RELAY.
- Tb - 15 MINUTE RUN-ON TIMER TO OPERATE UPON THE RETURN OF MAINS POWER.
- Cx - CONTACTOR x.
- CRx - CONTROL RELAY x.
- Rx - RELAY x.

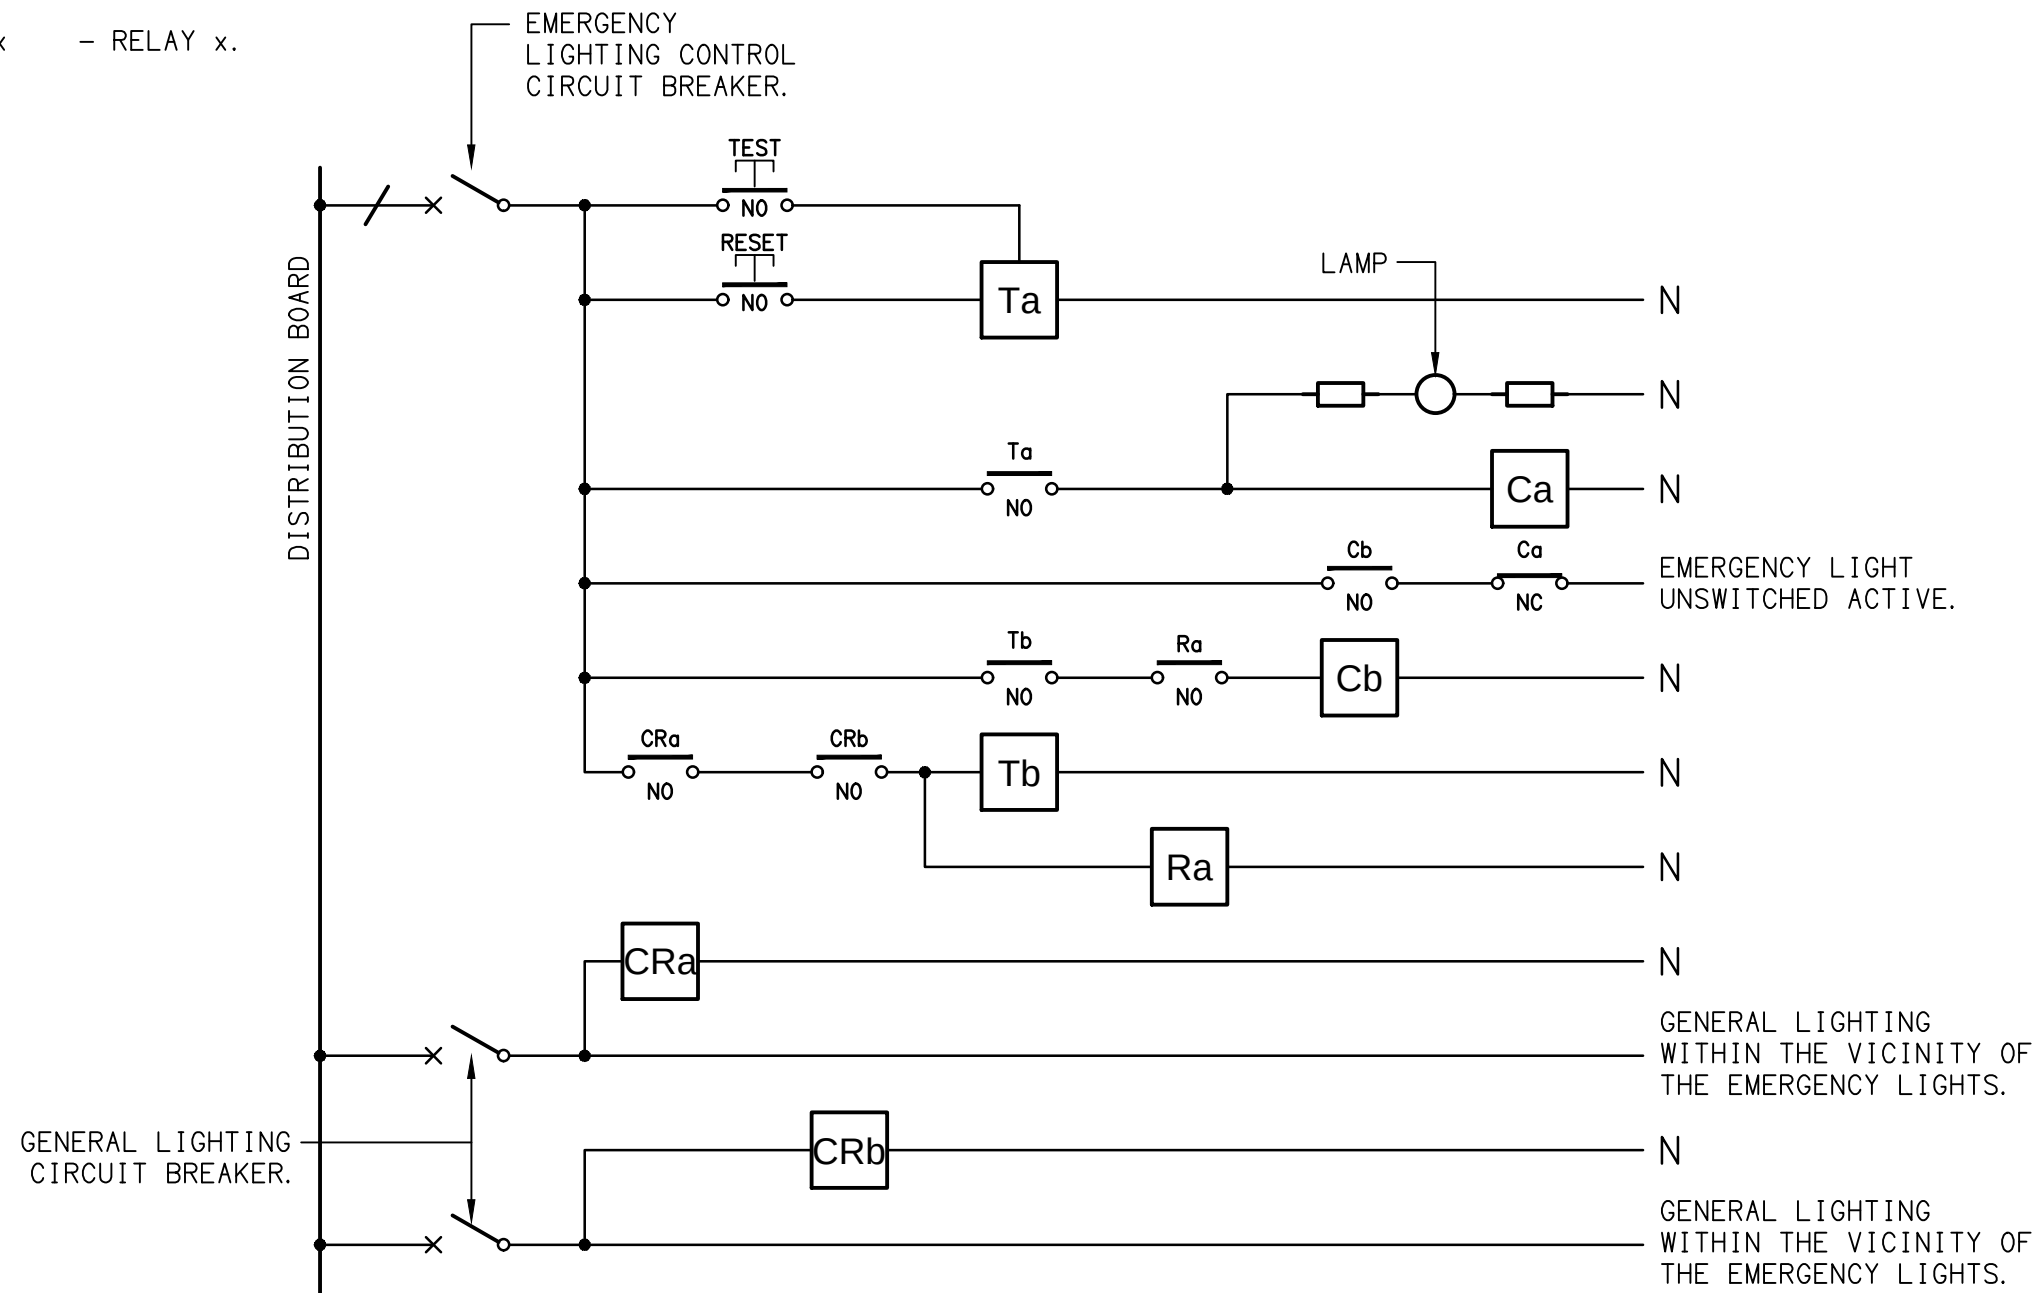

NOTES

- THE EMERGENCY LIGHT UNSWITCHED ACTIVE / GENERAL LIGHTING SWITCHED ACTIVE CIRCUIT ARRANGEMENT AND CONTROL IS TYPICAL FOR ALL CIRCUITS SUPPLYING EMERGENCY LIGHTS.
- PROVIDE ADDITIONAL CONTROL RELAYS (CRx) CONFIGURED AS PER CRa AND CRb FOR ALL ADDITIONAL LIGHTING CIRCUITS THAT SUPPLY LIGHTS IN THE VICINITY OF THE EMERGENCY LIGHTS.

SCHEMATIC  
EMERGENCY LIGHTING  
NOT TO SCALE

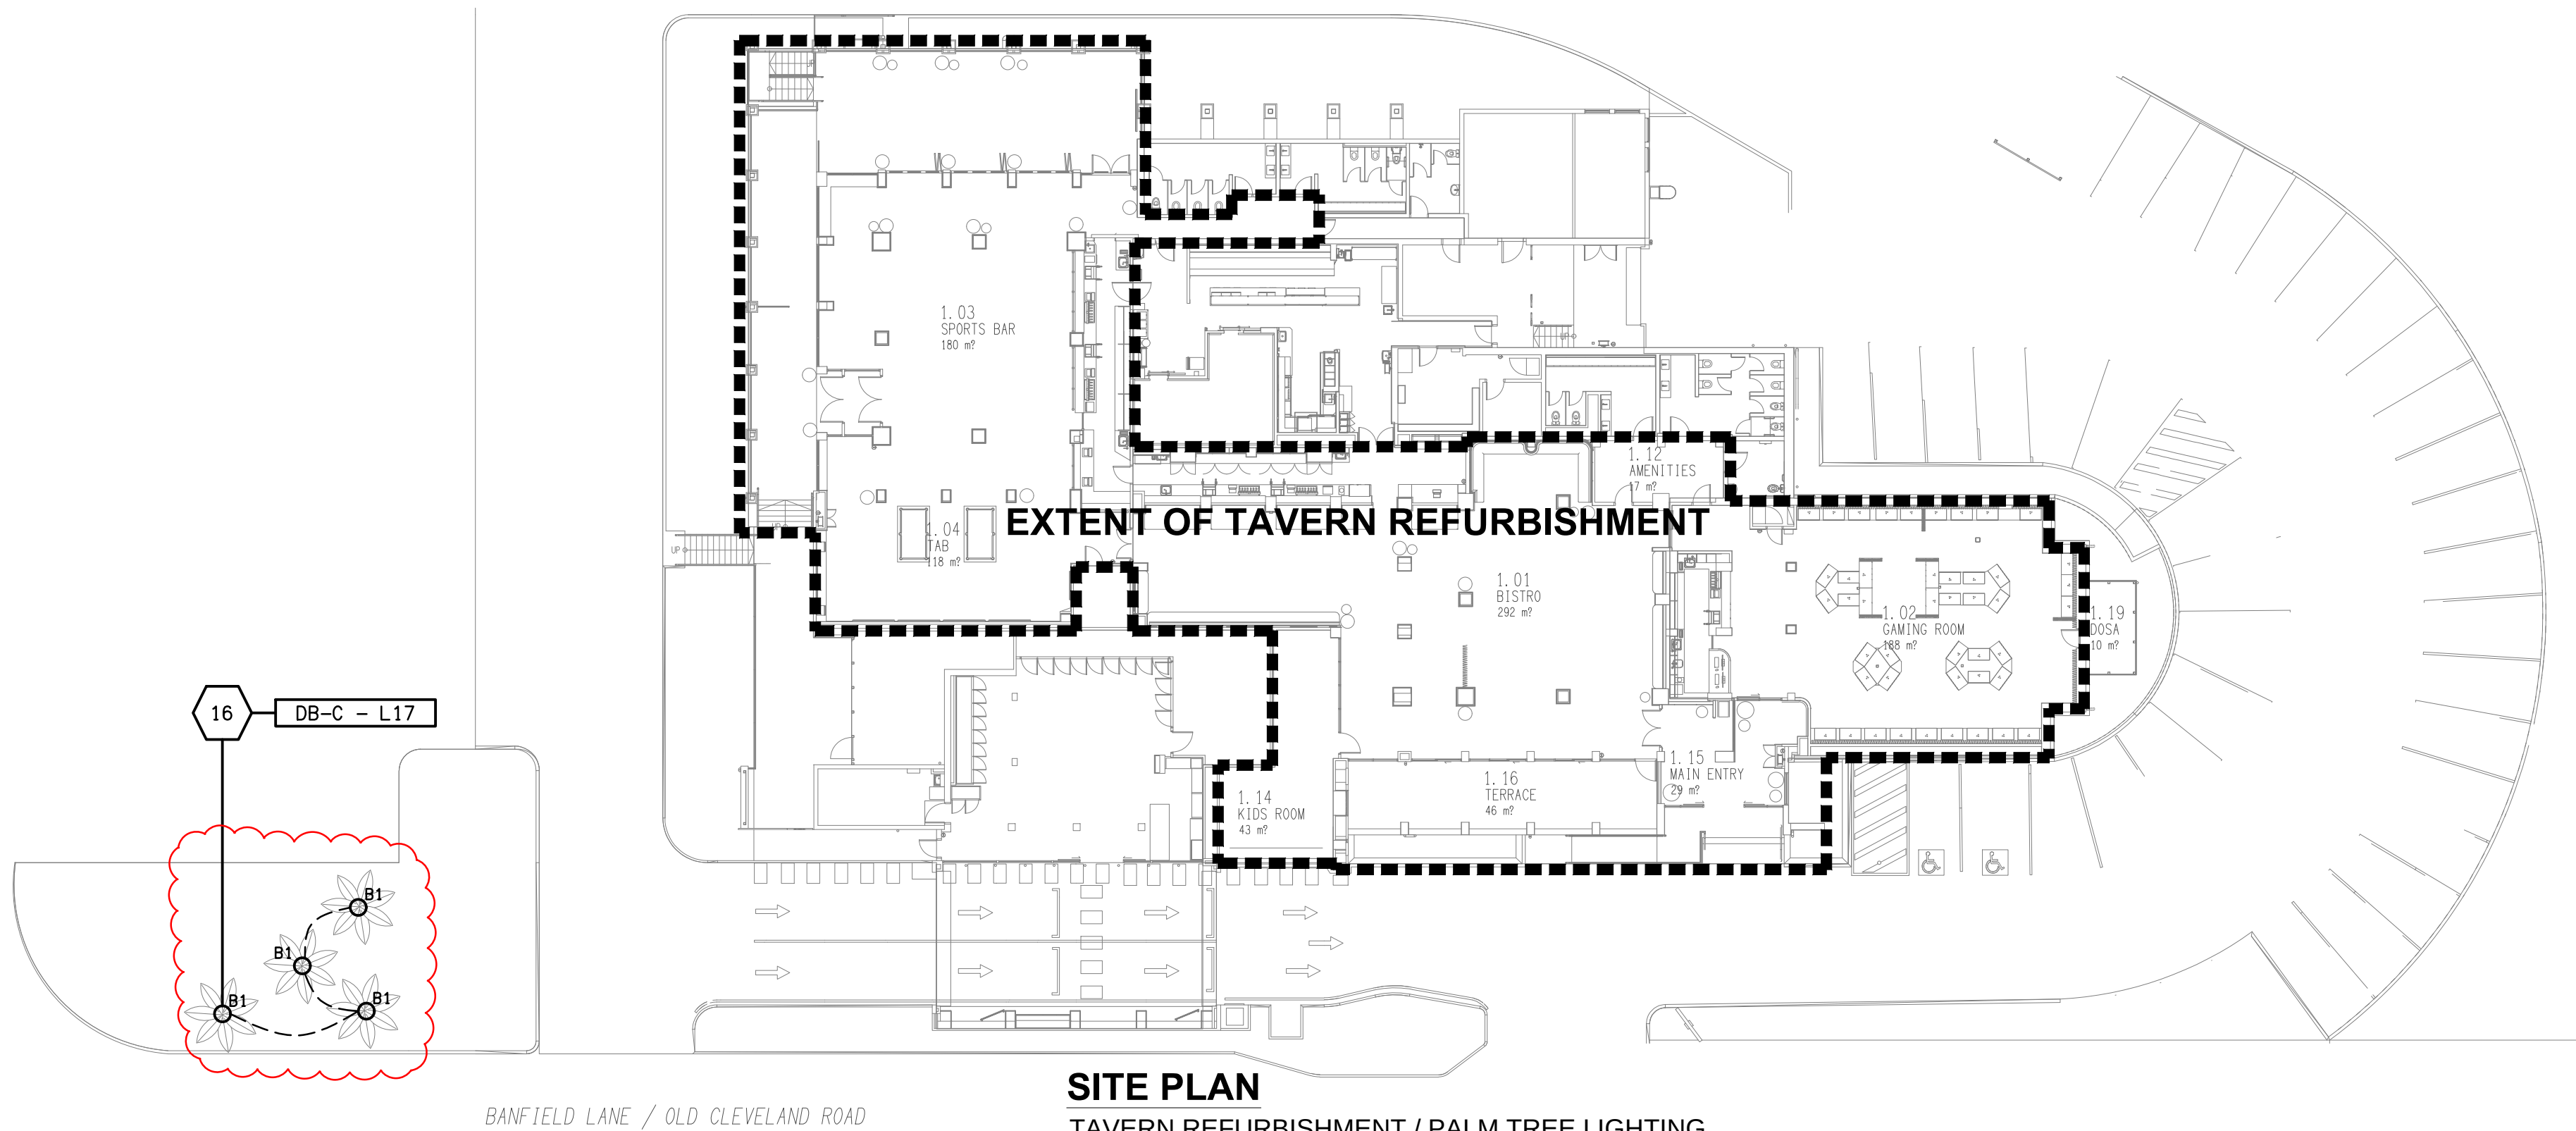

SITE PLAN  
TAVERN REFURBISHMENT / PALM TREE LIGHTING  
SCALE 1:250