



LEGEND


	TYPE	LAMPS	DESCRIPTION	COLOUR / ACCESSORY	CATALOGUE No
E1	E1	LED	EMERGENCY LIGHT- RECESSED NON-MAINTAINED EMERGENCY LIGHT C/W REMOTE BLUETOOTH ENABLED GALAXY EMERGENCY PACK	WHITE UNLESS NOTED AS BLACK (BK)	LEGRAND 659007LI
EX	EX	LED	EXIT LIGHT SURFACE MOUNTED - MAINTAINED 24M VIEWING DISTANCE EXIT LIGHT C/W DIFFUSERS & DIRECTIONAL ARROWS AS SHOWN. MOUNT BETWEEN 2100mm & 2700mm AFFL IF THERE IS NO VERTICAL SURFACE TO MOUNT THE FITTING ON WITHIN THIS RANGE CONFIRM THE MOUNTING HEIGHT WITH THE ENGINEER. INTEGRAL BLUETOOTH ENABLED GALAXY EMERGENCY PACK	WHITE	LEGRAND 659000LI
L1	L1	25W 4000K LED	600 x 600 BACK LIT LED PANEL C/W REMOTE DRIVER MOUNTED WITHIN THE CEILING T-BAR SYSTEM	WHITE	RAPID LED R3205-UGR19-25-CW
L2	L2	24W 4000K LED	RECESSED ADJUSTABLE DOWNLIGHT C/W REMOTE DRIVER	WHITE	RAPID LED R1306-WH-CW
L3	L3	14.4W / M 4000K LED	ROD SUSPENDED 50 X 70 EXTRUSION C/W OPAL DIFFUSER INTEGRAL DRIVER AND LED STRIP. CONFIRM THE LENGTHS VIA SITE MEASUREMENT.	WHITE	RAPID LED R2170-WH-CW
L4	L4	RELOCATE THE EXISTING RECESSED DOWNLIGHT REMOVED FROM THE BOARD ROOM TO THE NEW MEETING ROOM.			
F1	F1	EXISTING CEILING FAN ALONG WITH ALL ASSOCIATED CONTROLS TO BE REMOVED			
REM	REM	EXISTING OUTLET / FITTING TO BE REMOVED			
EXIST	EXIST	EXISTING OUTLET / FITTING TO REMAIN			
BK	BK	PROVIDE ANY OUTLET NOTED AS BK WITH A BLACK FACEPLATE			
EXIST	EXISTING POWER OUTLET	EXISTING POWER OUTLET TO REMAIN UNLESS NOTED AS BEING REMOVED OR RELOCATED.			
	NEW DOUBLE POWER OUTLET	DOUBLE POWER OUTLET C/W CIRCUIT IDENTIFICATION ON THE FACEPLATE BEHIND THE SURROUND MOUNT AT 300mm AFFL U.N.O. RATING 10A U.N.O.		WHITE UNLESS NOTED AS BLACK (BK)	CLIPSAL C2000 SERIES
EXIST	EXISTING COMMUNICATIONS OUTLET	EXISTING COMMUNICATIONS OUTLET TO REMAIN UNLESS NOTED AS BEING REMOVED OR RELOCATED.			
	NEW COMMUNICATIONS OUTLET	RJ45 CAT-6 COMMUNICATIONS OUTLET, CABLED BACK TO THE LOCAL COMMUNICATIONS RACK TERMINATED ONTO FACILITY PATCH PANELS VIA 4-PAIR CAT-6 UTP CABLE. MOUNT UP TO 3 RJ45 OUTLETS PER MULTI-GANG FACEPLATE WITH PRINTED PLASTIC LABEL USING COMMERCIAL ADHESIVE TO IDENTIFY EACH OUTLET PORT NUMBER.		WHITE UNLESS NOTED AS BLACK (BK)	CLIPSAL C2000 SERIES
EXIST	EXISTING SMOKE ALARM	SMOKE ALARM BY THE SECURITY CONTRACTOR			
	INTRUDER DETECTOR	INTRUDER DETECTOR BY THE SECURITY CONTRACTOR			
	ONE-WAY LIGHT SWITCH	ONE-WAY LIGHT SWITCH MOUNTED AT 1000mm AFFL UNLESS NOTED OTHERWISE.		WHITE	CLIPSAL C2000 SERIES 30USM USE ARCHITRAVE AS NECESSARY
	TWO-WAY LIGHT SWITCH	TWO-WAY LIGHT SWITCH MOUNTED AT 1000mm AFFL UNLESS NOTED OTHERWISE.		WHITE	CLIPSAL C2000 SERIES 30USM USE ARCHITRAVE AS NECESSARY
	PRESENCE DETECTOR	EXISTING LIGHTING CONTROL PRESENCE DETECTOR TO BE RELOCATED AND RECONFIGURED AS INDICATED			
SL1	ACCESS CONTROL SALTO EQUIPMENT 1 (SL1)	NEW ACCESS CONTROL SALTO EQUIPMENT BY THE SECURITY CONTRACTOR			
SL2	ACCESS CONTROL SALTO EQUIPMENT 2 (SL2)	EXISTING ACCESS CONTROL SALTO EQUIPMENT TO BE RELOCATED BY THE SECURITY CONTRACTOR			
CR-G	COMMUNICATIONS RACK G	EXISTING BLOCK G COMMUNICATIONS RACK ON LEVEL 2. PROVIDE CR-G WITH A NEW PATCH PANEL TO MATCH THE EXISTING TO ACCOMMODATE THE NEW BLOCK G COMMUNICATIONS OUTLETS.			
CR-D	COMMUNICATIONS RACK D	EXISTING BLOCK D COMMUNICATIONS RACK. PROVIDE CR-D WITH A NEW PATCH PANEL TO MATCH THE EXISTING TO ACCOMMODATE THE NEW BLOCK D COMMUNICATIONS OUTLETS.			
AV	AV RACK	EXISTING AV RACK. PROVIDE THE AV RACK WITH A NEW PATCH PANEL TO MATCH THE EXISTING CR-D PATCH PANELS TO ACCOMMODATE THE NEW ADMIN BLOCK COMMUNICATIONS OUTLETS.			
A1	A1	PROVIDE A1 AS MULTIPLE WALL MOUNTED FACEPLATES AND CABLING AS PER THE AV OUTLET CONFIGURATION SCHEMATIC AND INTERNAL ELEVATIONS. THE USB AND HDMI CABLES ARE TO BE FACTORY TERMINATED. PROVIDE THE GPO AS A CONVENTIONAL GPO CIRCUITED AS SHOWN AND THE RJ45 OUTLETS AS CONVENTIONAL COMMUNICATIONS OUTLETS CABLED TO THE LOCAL COMMUNICATIONS RACK.		WHITE UNLESS NOTED OTHERWISE	CLIPSAL C2000 SERIES
A2	A2	PROVIDE A2 AS MULTIPLE WALL MOUNTED FACEPLATES AND CABLING AS PER THE AV OUTLET CONFIGURATION SCHEMATIC AND INTERNAL ELEVATIONS. THE USB AND HDMI CABLES ARE TO BE FACTORY TERMINATED. PROVIDE THE GPO AS A CONVENTIONAL GPO CIRCUITED AS SHOWN AND THE RJ45 OUTLETS AS CONVENTIONAL COMMUNICATIONS OUTLETS CABLED TO THE LOCAL COMMUNICATIONS RACK.		WHITE UNLESS NOTED OTHERWISE	CLIPSAL C2000 SERIES
A3	A3	RELOCATE THE EXISTING A3 MULTIPLE WALL MOUNTED FACEPLATES AND CABLING AS PER THE AV OUTLET CONFIGURATION SCHEMATIC TO TEH NEW TV LOCATION. THE HDMI CABLES ARE TO BE FACTORY TERMINATED. PROVIDE THE GPO AS A CONVENTIONAL GPO CIRCUITED AS SHOWN AND THE RJ45 OUTLETS AS CONVENTIONAL COMMUNICATIONS OUTLETS CABLED TO THE LOCAL COMMUNICATIONS RACK.		WHITE UNLESS NOTED OTHERWISE	CLIPSAL C2000 SERIES
A4	A4	RELOCATE THE EXISTING MULTIPLE OUTLETS MOUNTED WITHIN THE DESK JOINERY TO THE NEW DESK LOCATION. THE FACEPLATES AND CABLING AS PER THE AV OUTLET CONFIGURATION SCHEMATIC. THE HDMI CABLES ARE TO BE FACTORY TERMINATED. PROVIDE THE GPO AS A CONVENTIONAL GPO CIRCUITED AS SHOWN AND THE RJ45 OUTLETS AS CONVENTIONAL COMMUNICATIONS OUTLETS CABLED TO THE LOCAL COMMUNICATIONS RACK.		WHITE UNLESS NOTED OTHERWISE	CLIPSAL C2000 SERIES
	AV SPEAKER	EXISTING AV SPEAKER TO BE ADDRESSED BY THE AV CONTRACTOR			

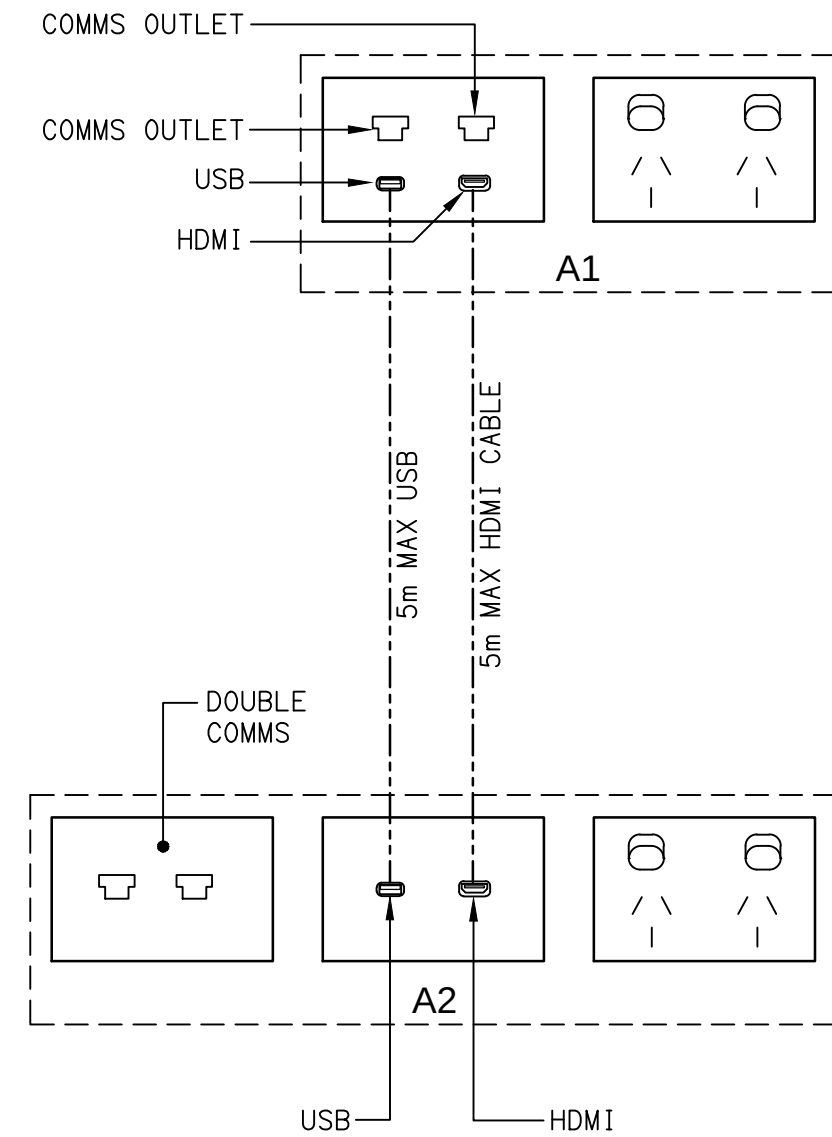

DETAIL A
A1 & A2 FACEPLATE CONFIGURATION
NOT TO SCALE

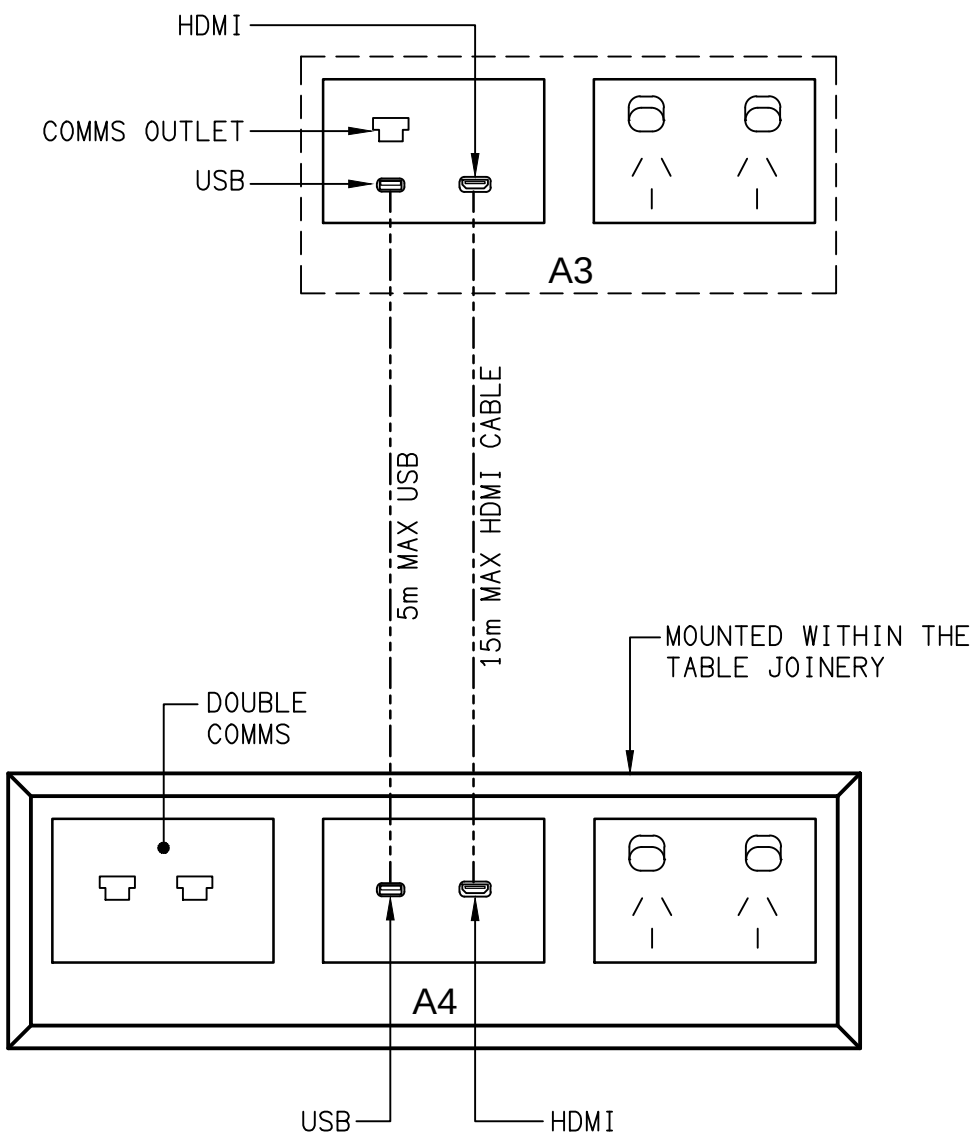

DETAIL B
A3 & A4 FACEPLATE CONFIGURATION
NOT TO SCALE

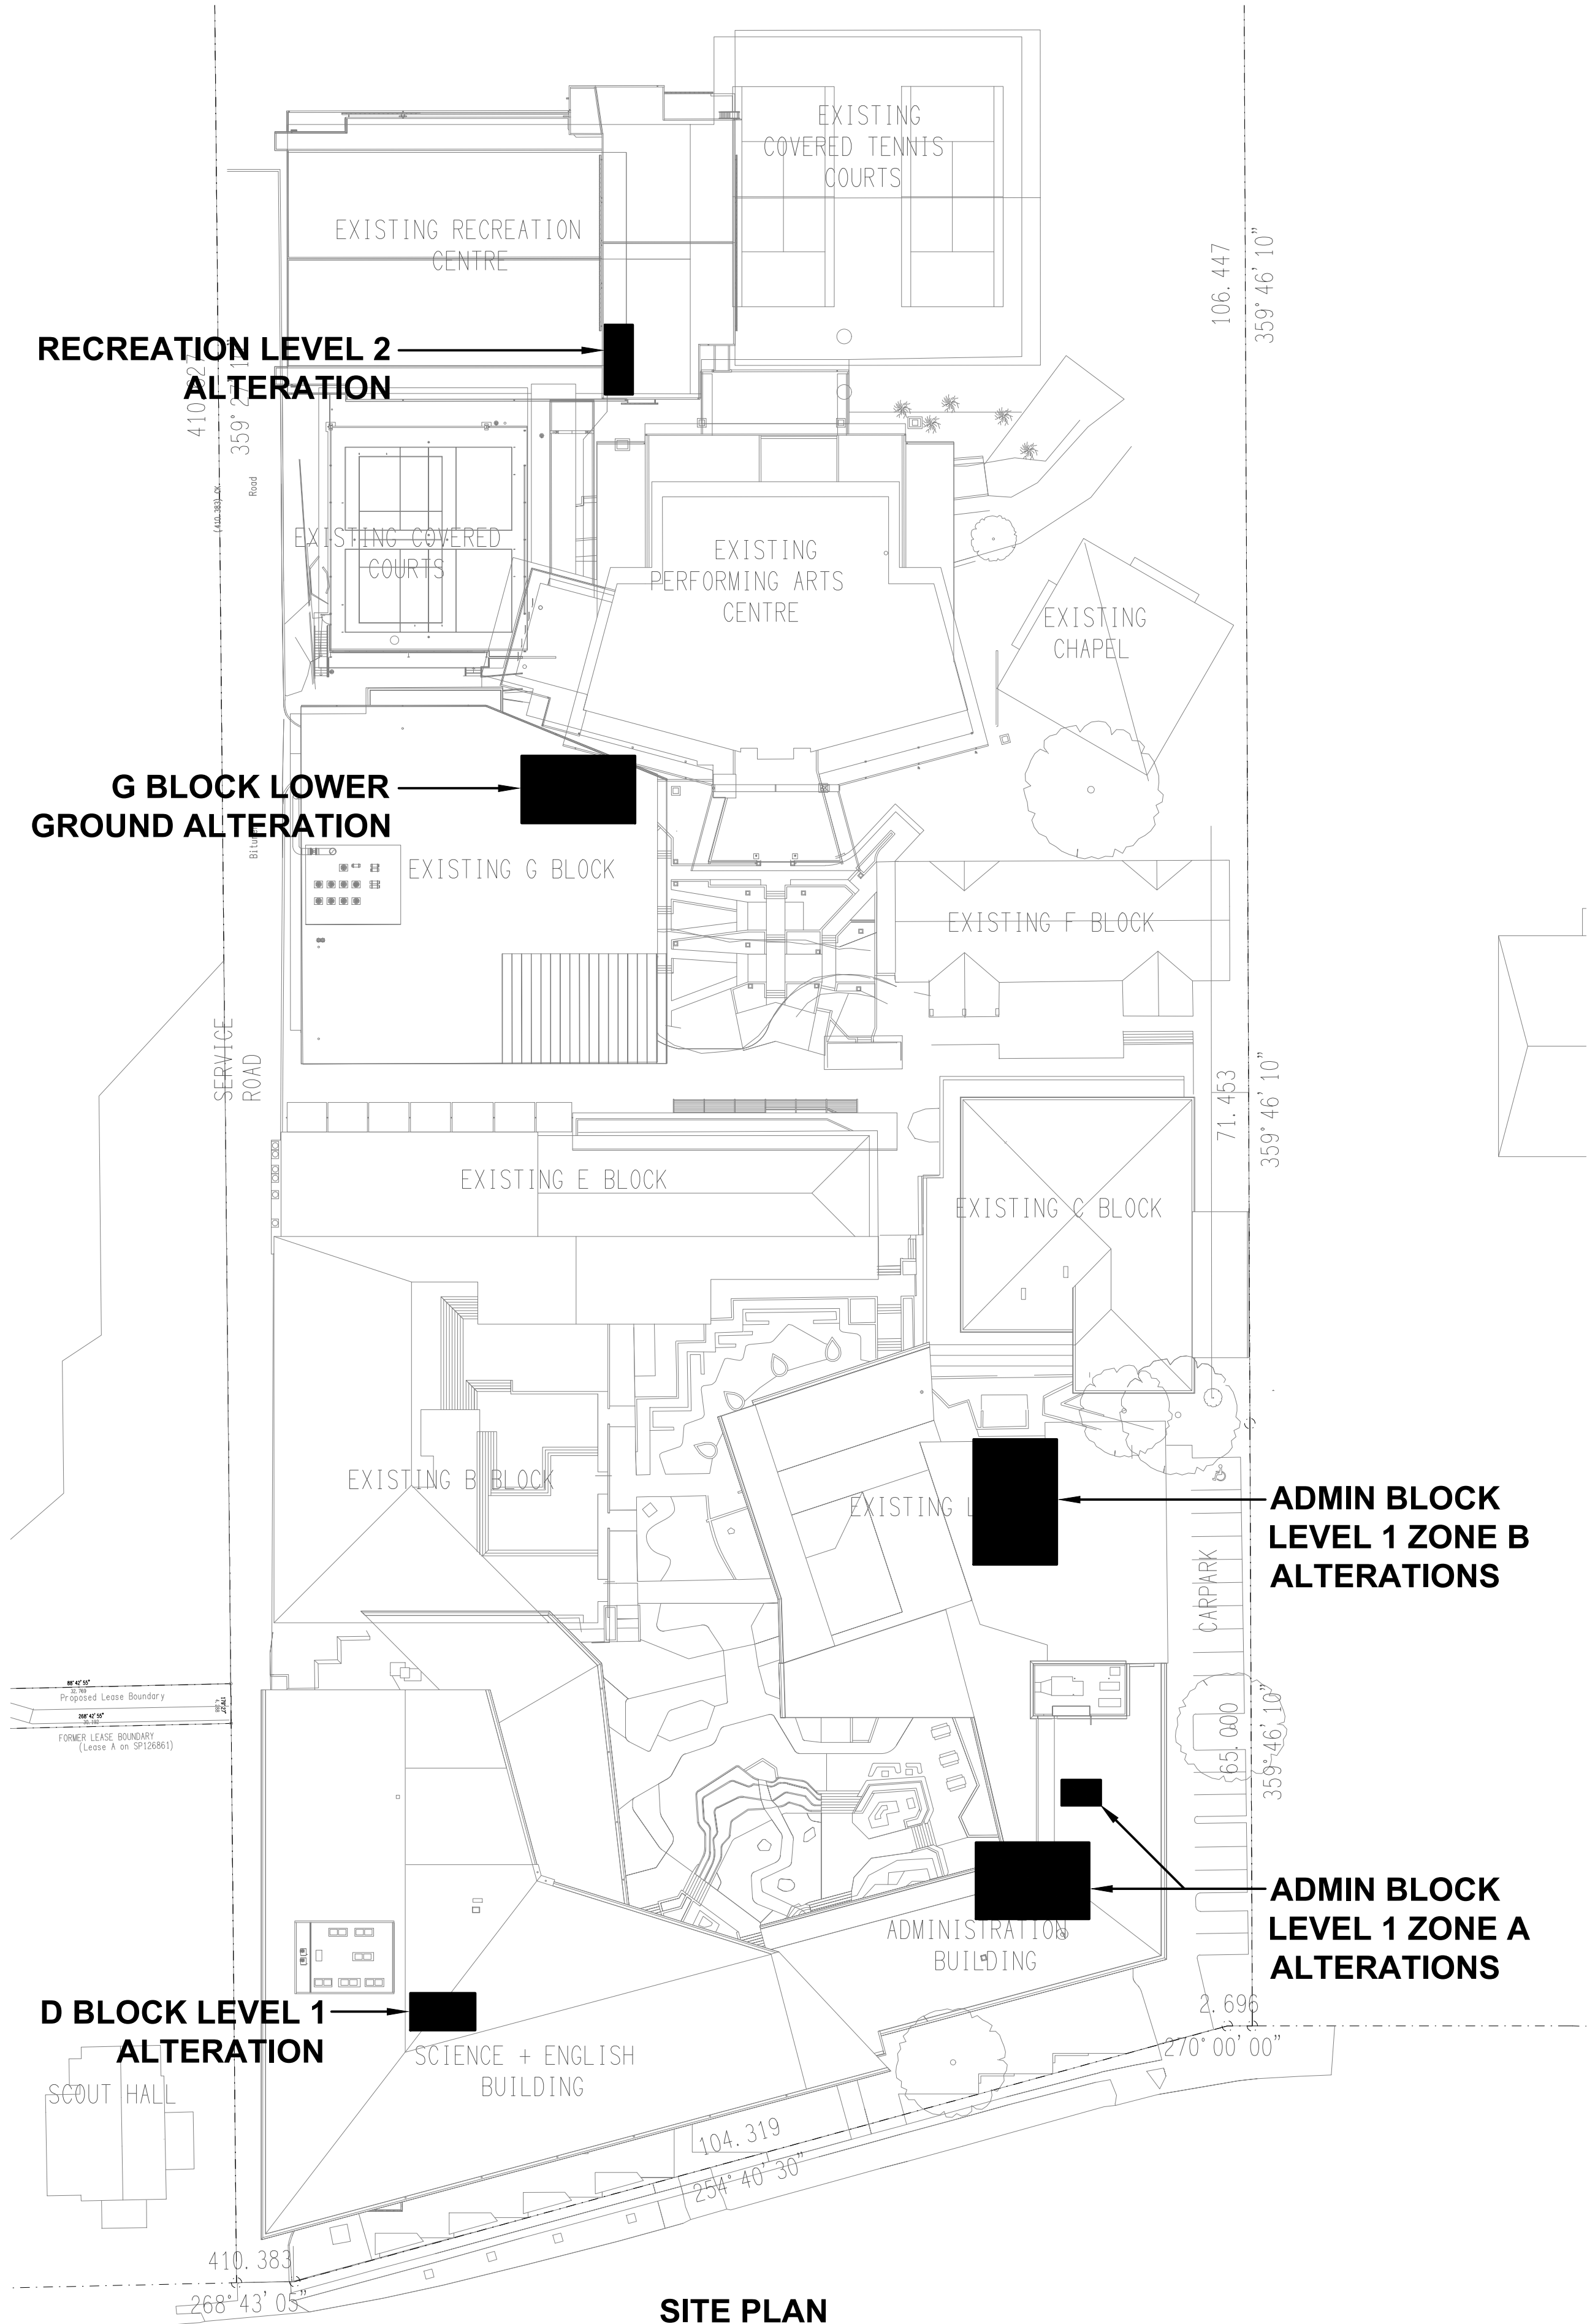

SITE PLAN
ALTERATION LOCATIONS
SCALE 1:500